

EXTERIOR LIGHT SPEC'S_LIGHT A



SPECIFICATIONS	
ITEM NUMBER	F6891-31
DESCRIPTION	SQUARE SCONCE
MATERIAL	ALUMINUM
FINISH	BLACK (31)
MOUNTING	WALL
WARRANTY	5 YR LIMITED
INSTALLATION	WET

ELECTRICAL	
SCENE NAME	RECEIVER NAME - 1000
NUMBER OF BULBS	1
WATTAGE FOR BULBS	50W / 75W
MAXIMUM WATTAGE	50W / 75W
VOLTS	120V
LIGHT BULB	50W OR 75W
SCENE SETTING	50W OR 75W
50W WITH PAIR 20	
75W WITH PAIR 20	

DIMENSIONS	
HEIGHT	4.31"
WIDTH	4.31"
EXTENSION	5.11"

NOTE:
EXTERIOR LIGHTING FIXTURES
SHALL BE SHIELDED, SO AS
NOT TO SHINE ON ADJACENT
PROPERTIES.
LUMINANCE F6891-31 EXTERIOR WALL SCONCE,
50PAR20/FL, ALUMINUM FINISH

EXTERIOR LIGHT SPEC'S_LIGHT B

Elements

LED Non-Cutoff Wall Pack - Polycarbonate Lens

Applications

This product family can be effectively used in outdoor wall mount locations. Commercial, industrial, retail and healthcare exterior lighting; parking lot, cargo door, high wall, area, security, etc.

Construction

- Die-cast aluminum housing
- Impact resistant polycarbonate lens
- Durable dark bronze powdercoat
- Same footprint as existing HLD wall packs

Electrical

- ULus wet location rated
- Easy-access wiring compartment
- System rated for long 50,000 hour life
- Efficiently delivers up to 125 LPW

Optics

- Prismatic polycarbonate lens
- Delivers bright, white light and excellent uniformity

LED Technical Data

Item Number	Notes	Type

Warranty

Five year limited warranty against defects in manufacturing.

Listings

UL and cUL listed
RoHS Compliant

Front View

Side View


ITEM #	DESCRIPTION	LUMENS	WATTAGE	LPW	VOLTAJE	POWER FACTOR	CEI	LED	WET	ULus	WELL	WELL
LED Wall Pack - 50,000 Hour												
WP5000140	LED Wall Pack - Non Dim 40K	6900	55	125.5	120-277V	>0.9	4000K	>80	50000	14.2	9.2	7.4
WP5000150	LED Wall Pack - Non Dim 50K	6900	55	125.5	120-277V	>0.9	5000K	>80	50000	14.2	9.2	7.4
WP5000140PC	LED Wall Pack - Non Dim 40K W/PC	6900	55	125.5	120-277V	>0.9	4000K	>80	50000	14.2	9.2	7.4
WP5000150PC	LED Wall Pack - Non Dim 50K W/PC	6900	55	125.5	120-277V	>0.9	5000K	>80	50000	14.2	9.2	7.4
WP12000140	LED Wall Pack - Non Dim 40K	14500	120	120.8	120-277V	>0.9	4000K	>80	50000	14.2	9.2	7.4
WP12000150	LED Wall Pack - Non Dim 50K	14500	120	120.8	120-277V	>0.9	5000K	>80	50000	14.2	9.2	7.4
WP12000140PC	LED Wall Pack - Non Dim 40K W/PC	14500	120	120.8	120-277V	>0.9	4000K	>80	50000	14.2	9.2	7.4
WP12000150PC	LED Wall Pack - Non Dim 50K W/PC	14500	120	120.8	120-277V	>0.9	5000K	>80	50000	14.2	9.2	7.4

TCP

we know light.™


"BRADFORD" GALLERY PEAR TREE.
6" CALIPER
14'-0" AT TIME OF PLANTING

NOTE:
BALL OF ALL PLANTS TO BE KEPT MOIST AND
PROTECTED FROM DAMAGE PRIOR TO PLANTING.
PROVIDE 3'x6" TREE PIT.
USE STAKES, GUYS & TREE WRAP ONLY WHEN CONDITIONS
WARRANT.
REMOVE ALL NON-BIODEGRADABLE MATERIALS & WIRE
BASKETS FROM ROOTBALL.

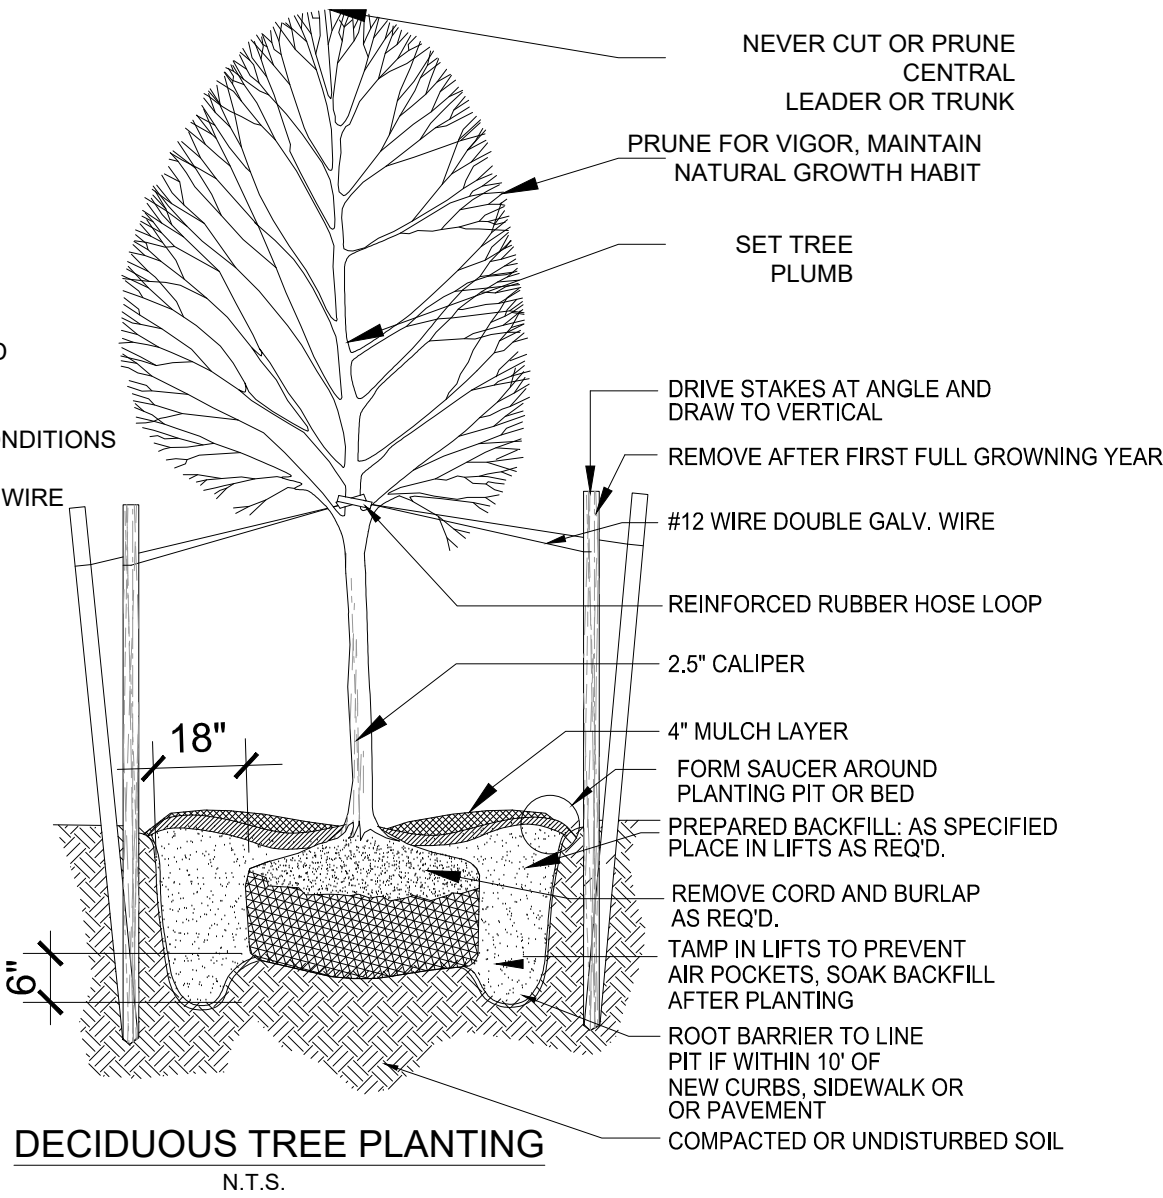

DECIDUOUS TREE PLANTING
N.T.S.

SITE PLAN_EXISTING AND PROPOSED

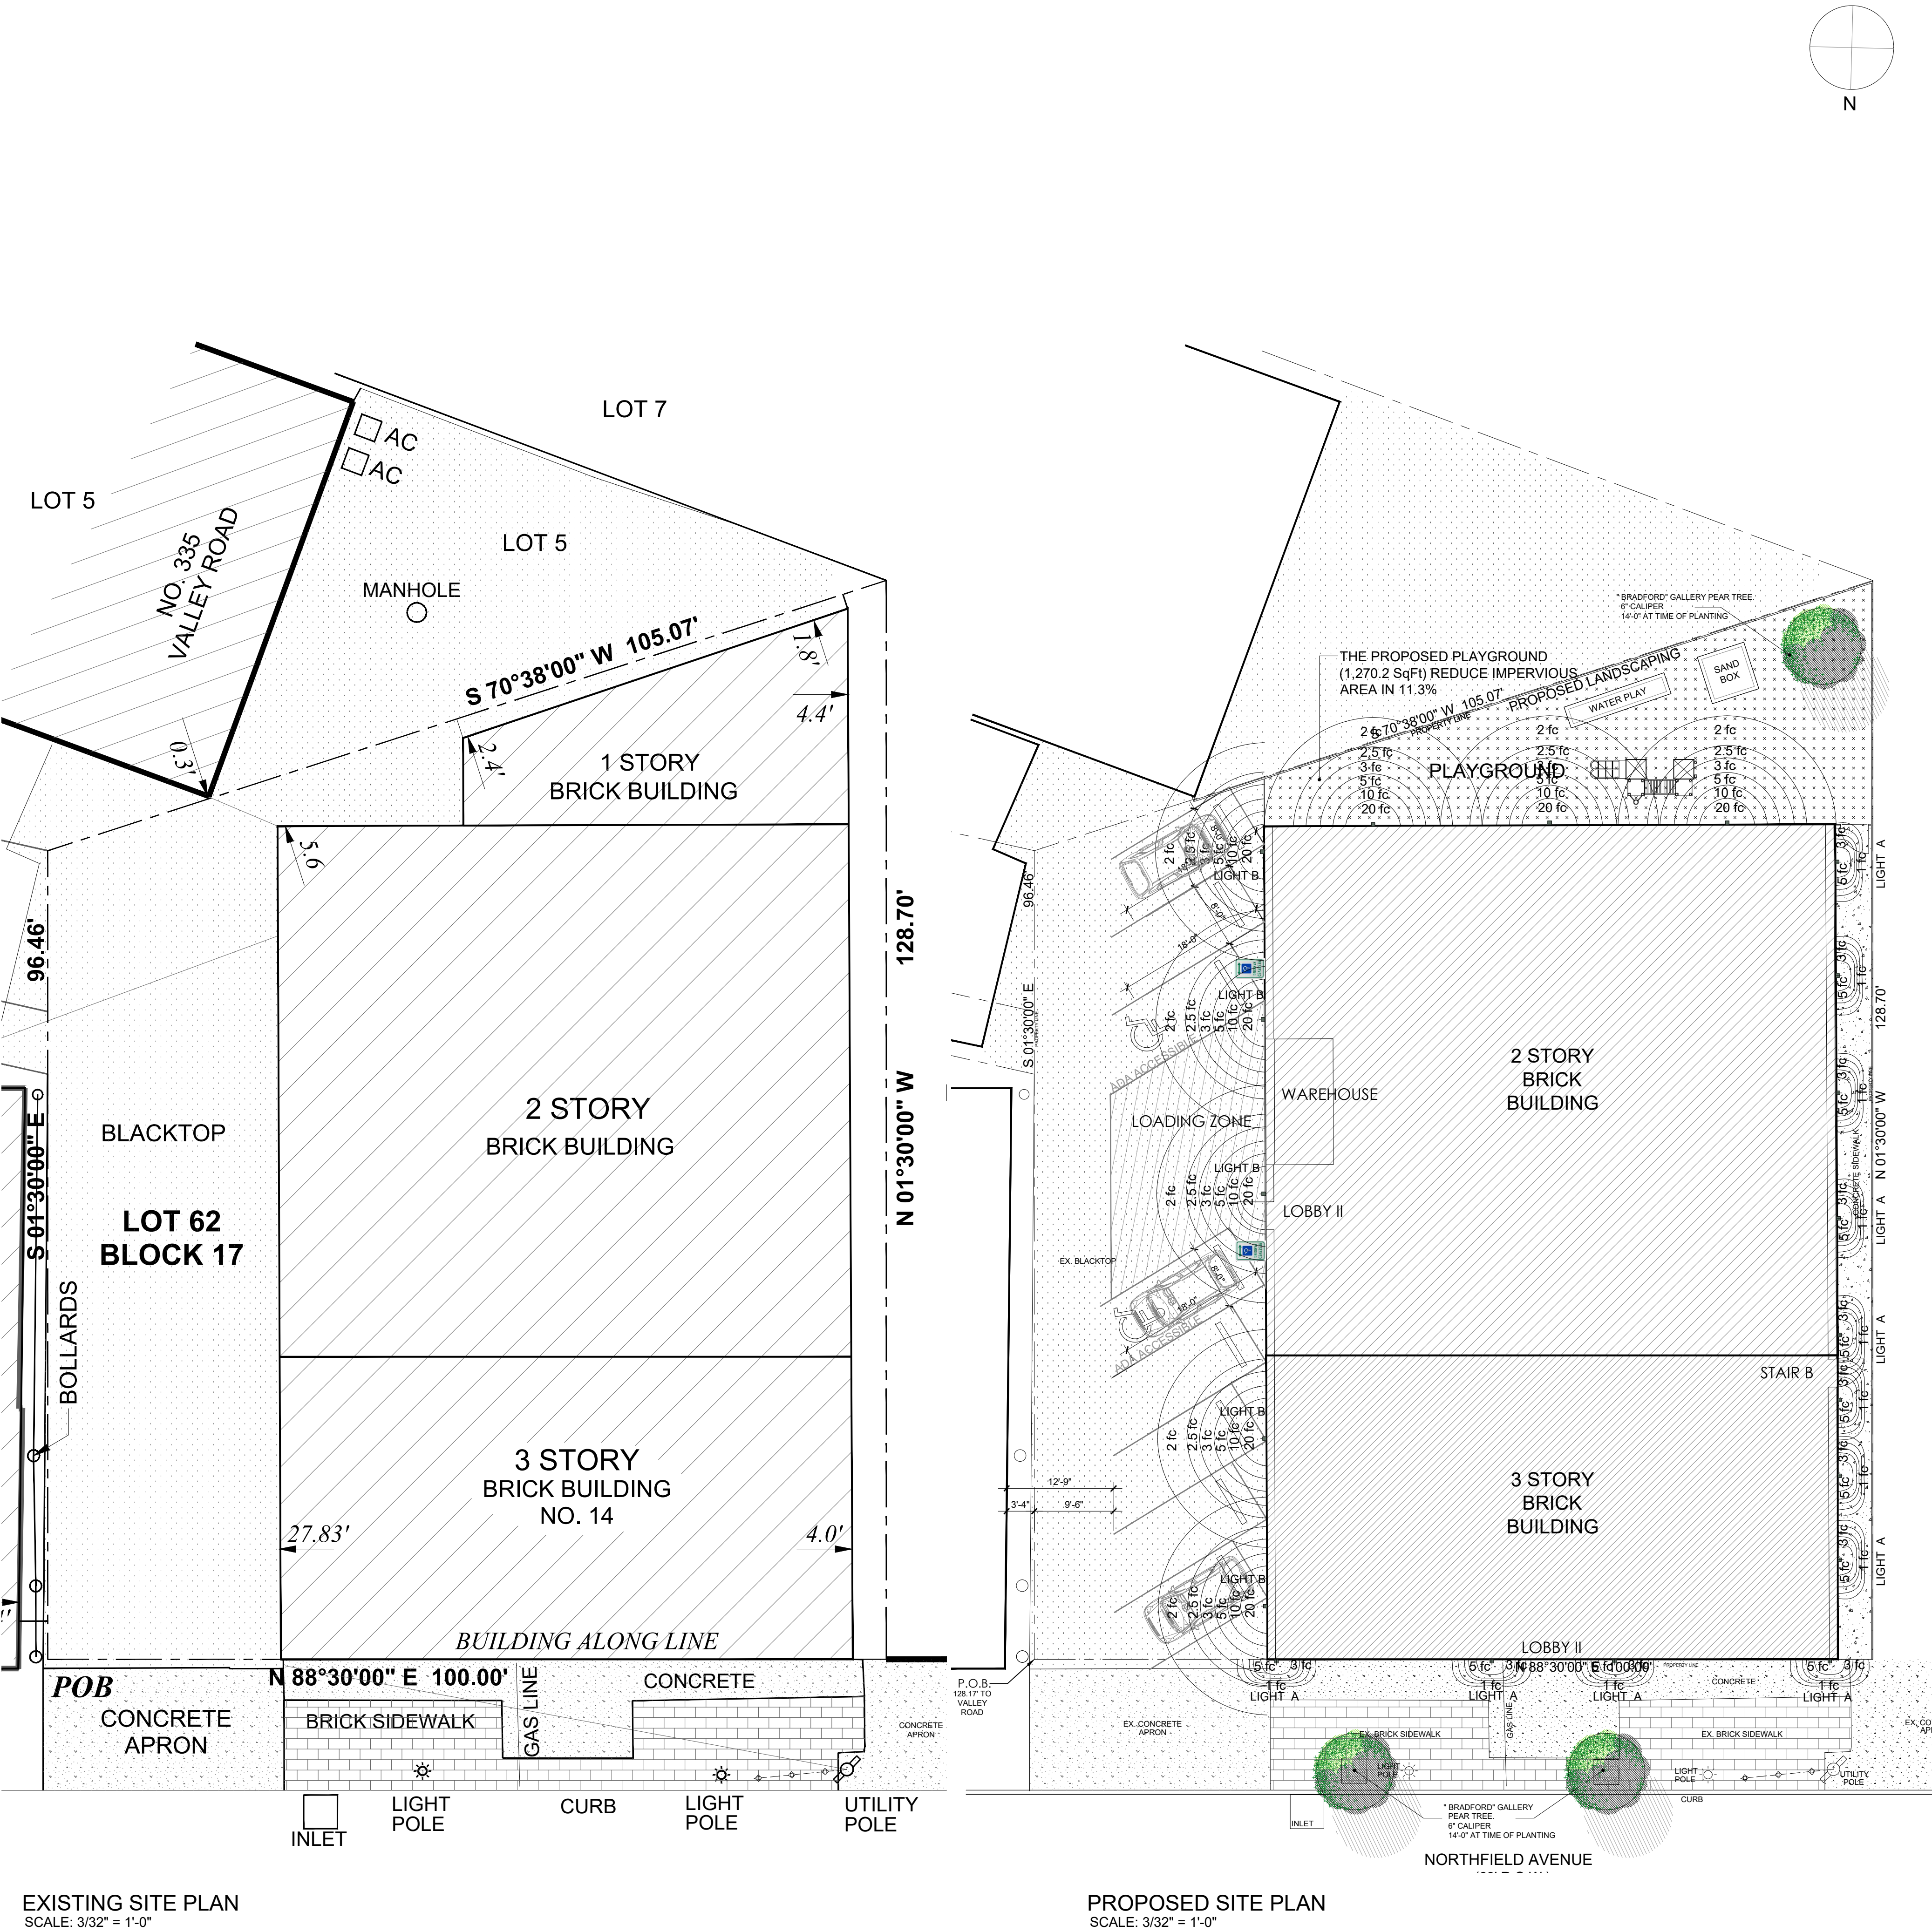

JAI

architect LLC

JOSE A. IZQUIERDO, AIA
NJ LIC. 009143 NY LIC. 001704-1 NJ P.E.N. 003385

391 Nelson Avenue
Cliffside Park, NJ 07010
CELL - 201-240-7484

Jose A. Izquierdo, AIA, PP, JD
JAarchitects@gmail.com

Date Sealed: 12 / 14 / 2022

These plans are the intellectual property of
the JAI Architect, LLC and may not be
copied, re-used or altered in any way
without JAI's express written consent.

REVISIONS		
NO.	DESCRIPTION	DATE
1.	Planning Board Submission	12/12/2022

SUBMISSIONS		
NO.	DESCRIPTION	DATE
1.	Planning Board Submission	09/30/2022

NAUC 5:23-6:31 CHANGE OF USE
NAUC 5:23-6:3 RECONSTRUCTION
14-16 NORTHFIELD AVE
WEST ORANGE-NJ 07052
BLOCK 17 LOT 62

OWNER

DO WELL MANAGEMENT
Mr Richard Herbst

CONTRACTOR TO VERIFY ALL FIELD
CONDITIONS AND DIMENSIONS PRIOR
TO COMMENCING. REPORT ALL
DISCREPANCIES TO ARCHITECT.
COMMENCEMENT OF WORK IMPLIES
ACCEPTANCE OF FIELD CONDITIONS
AND DIMENSIONS.

PROJECT

MIXED USE BUILDING
RE-CONSTRUCTION &
CHANGE OF USE

SHEET TITLE

OPTION B
EXISTING AND PROPOSED
SITE PLAN & SITE DETAILS

SCALE	AS NOTED
DATE	06-30-2022
JOB NO	2022.27

T02