


THIS DRAWING IS COPYRIGHTED AND PROTECTED UNDER THE LAWS OF THE UNITED STATES OF AMERICA. ANY UNAUTHORIZED USE OR REPRODUCTION OF THIS DOCUMENT WITHOUT WRITTEN CONSENT OF ROBERT A. GRIMALDI IS AN INFRINGEMENT UPON COPYRIGHT LAWS. VIOLATORS WILL BE SUBJECT TO PROSECUTION BY THE FULL EXTENT OF THE LAW.

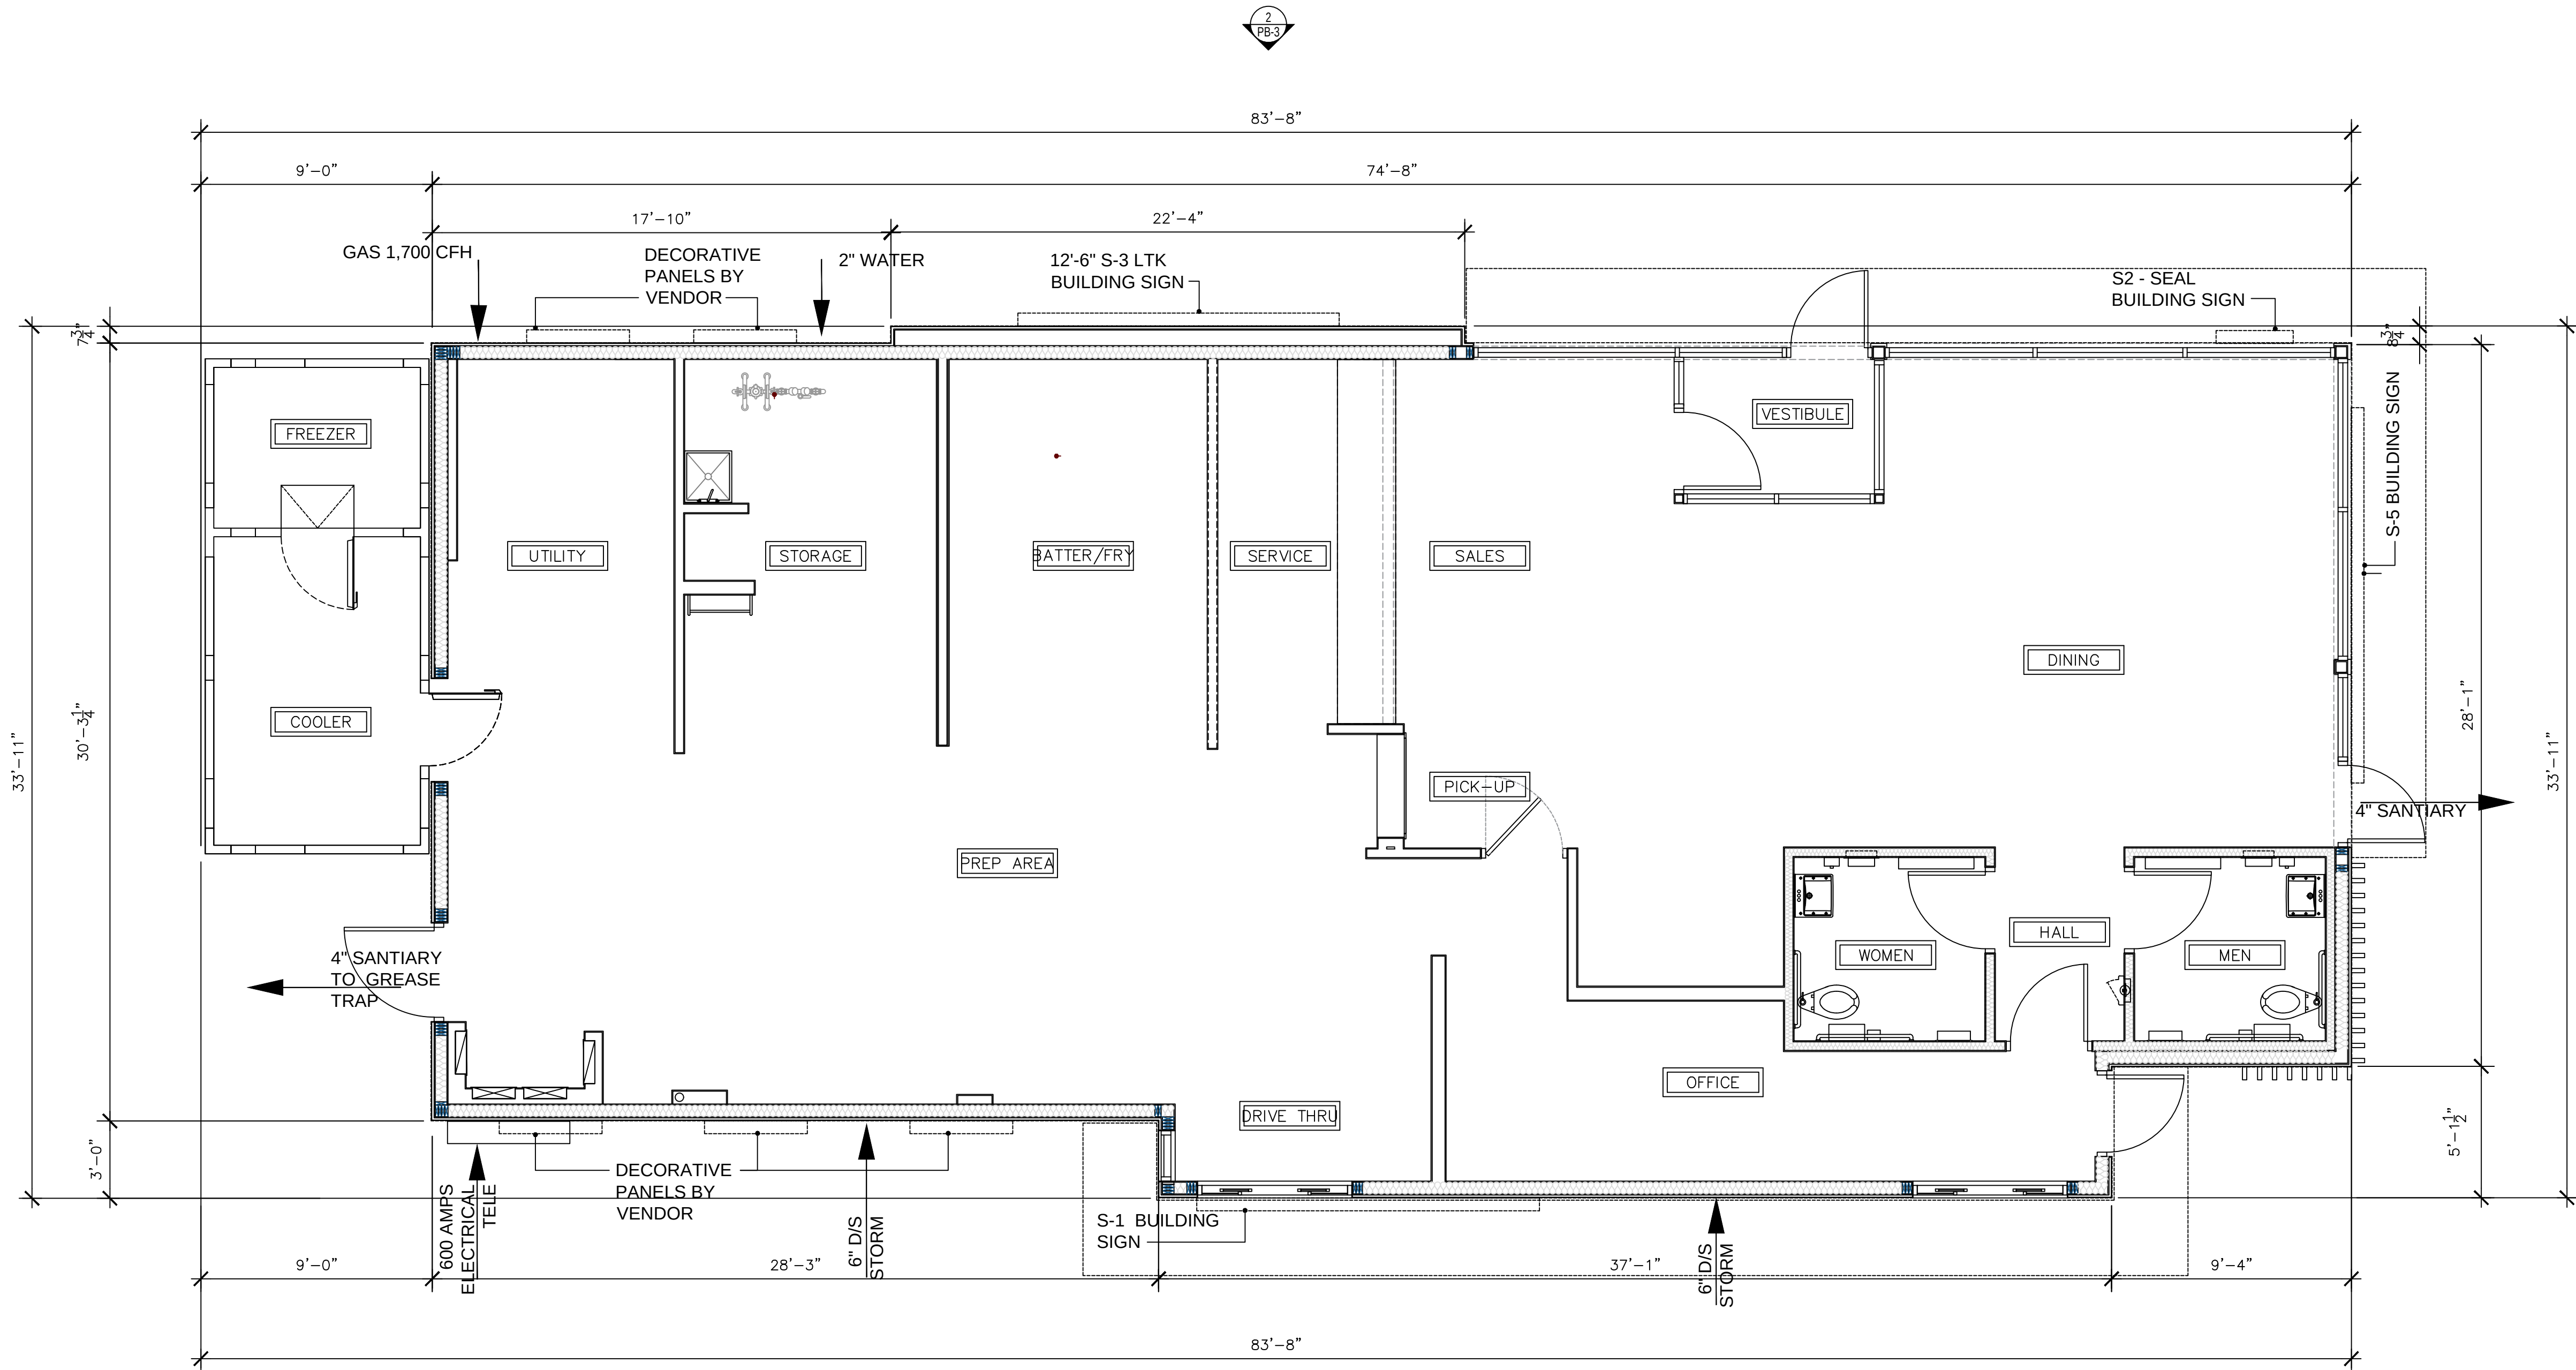

1
PB-1
PROPOSED FLOOR PLAN
1/4" = 1'-0"

BUILDING AREA CALCULATIONS

TOTAL BUILDING AREA (GROSS):	2,357 SF
TOTAL WALKIN COOLER/FREZER:	168 SF
BUILDING HEIGHT:	21'-10" PROVIDED
24 CUSTOMERS SEATS	

Electrical Service: 600 Amps 100% Rated at 208/120 Volt, 3 Phase, 4 Wire
Actual Demand Load = 579 Amps.

Gas Service: 1,700 CFH at 7 - 14 inches of Water Column.
Actual Demand Load = 1,658 CFH

Baseline Case: change occupant values to reflect anticipated occupancy					
Fixture Type	Consumption	Daily Uses	Duration	Occupants	Daily Water Use (gal)
1.6 gpf toilet - male (gallons per flush)	1.6	1	1	250	400
1.6 gpf toilet - female (gallons per flush)	1.6	3	1	250	1,200
1.0 gpf urinal - male (gallons per flush)	1	2	1	0	-
Commercial Lavatory Faucet - 1.0 gpm	1	3	0.25	500	375
Kitchen sink - 2.2 gpm	2.2	1	0.25	500	275
misc - 2.5 gpm	2.5	0.1	8	500	1,000
Total Daily Volume					3,250
Annual Work Days					364
Total Annual Usage					1,183,000

G 141 ARCHITECTURE, LLC


G141

ARCHITECTURE, LLC

ROBERT ANTHONY GRIMALDI
39 NORTH 11th STREET
KENILWORTH, NJ 07033
g141office@gmail.com
908-347-7419

NCARB 84690
AIA 38640695

CT 13585
DE S5-0008497
DC AEC103027
MA 951751
MD 18745
NJ AI 15475
NH 04842
NY 039330
OH ARC.2018210
PA AR07639
VA 0401019058

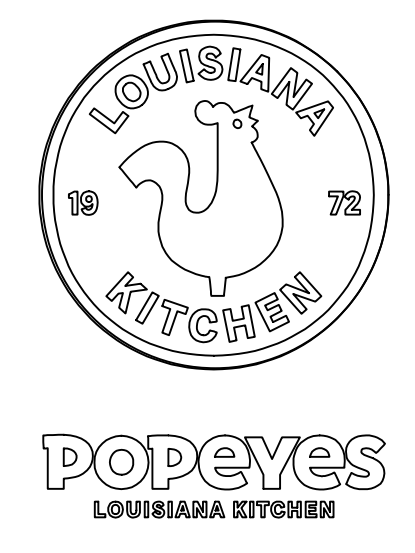

POPEYES LOUISIANNA KITCHEN
470 EAGLE ROCK AVE.
WEST ORANGE - NJ
PROPOSED FLOOR PLAN

Revisions
△ :
△ :
△ :
△ :
△ :
△ :


Drawn By MHS
Checked By RAG
Scale AS NOTED
Date 2021-11-10

Job No. 21-0032
Sheet No. PB-1



INSULATION CHARTS		
VENEER THICKNESS	INSULATION THICKNESS	R-VALUE
1/2" VENEER	UP TO 2"	R-2.5 to R-10
3/4" VENEER	UP TO 1.5"	R-2.5 to R-7.5
1" VENEER	UP TO 1"	R-2.5 to R-5

Revisions △ : _____ △ : _____ △ : _____ △ : _____ △ : _____	
Drawn By MHS	Checked By RAG
Scale AS NOTED	Date 2021-11-10
Job No. 21-00032	
Sheet No. PB-3	

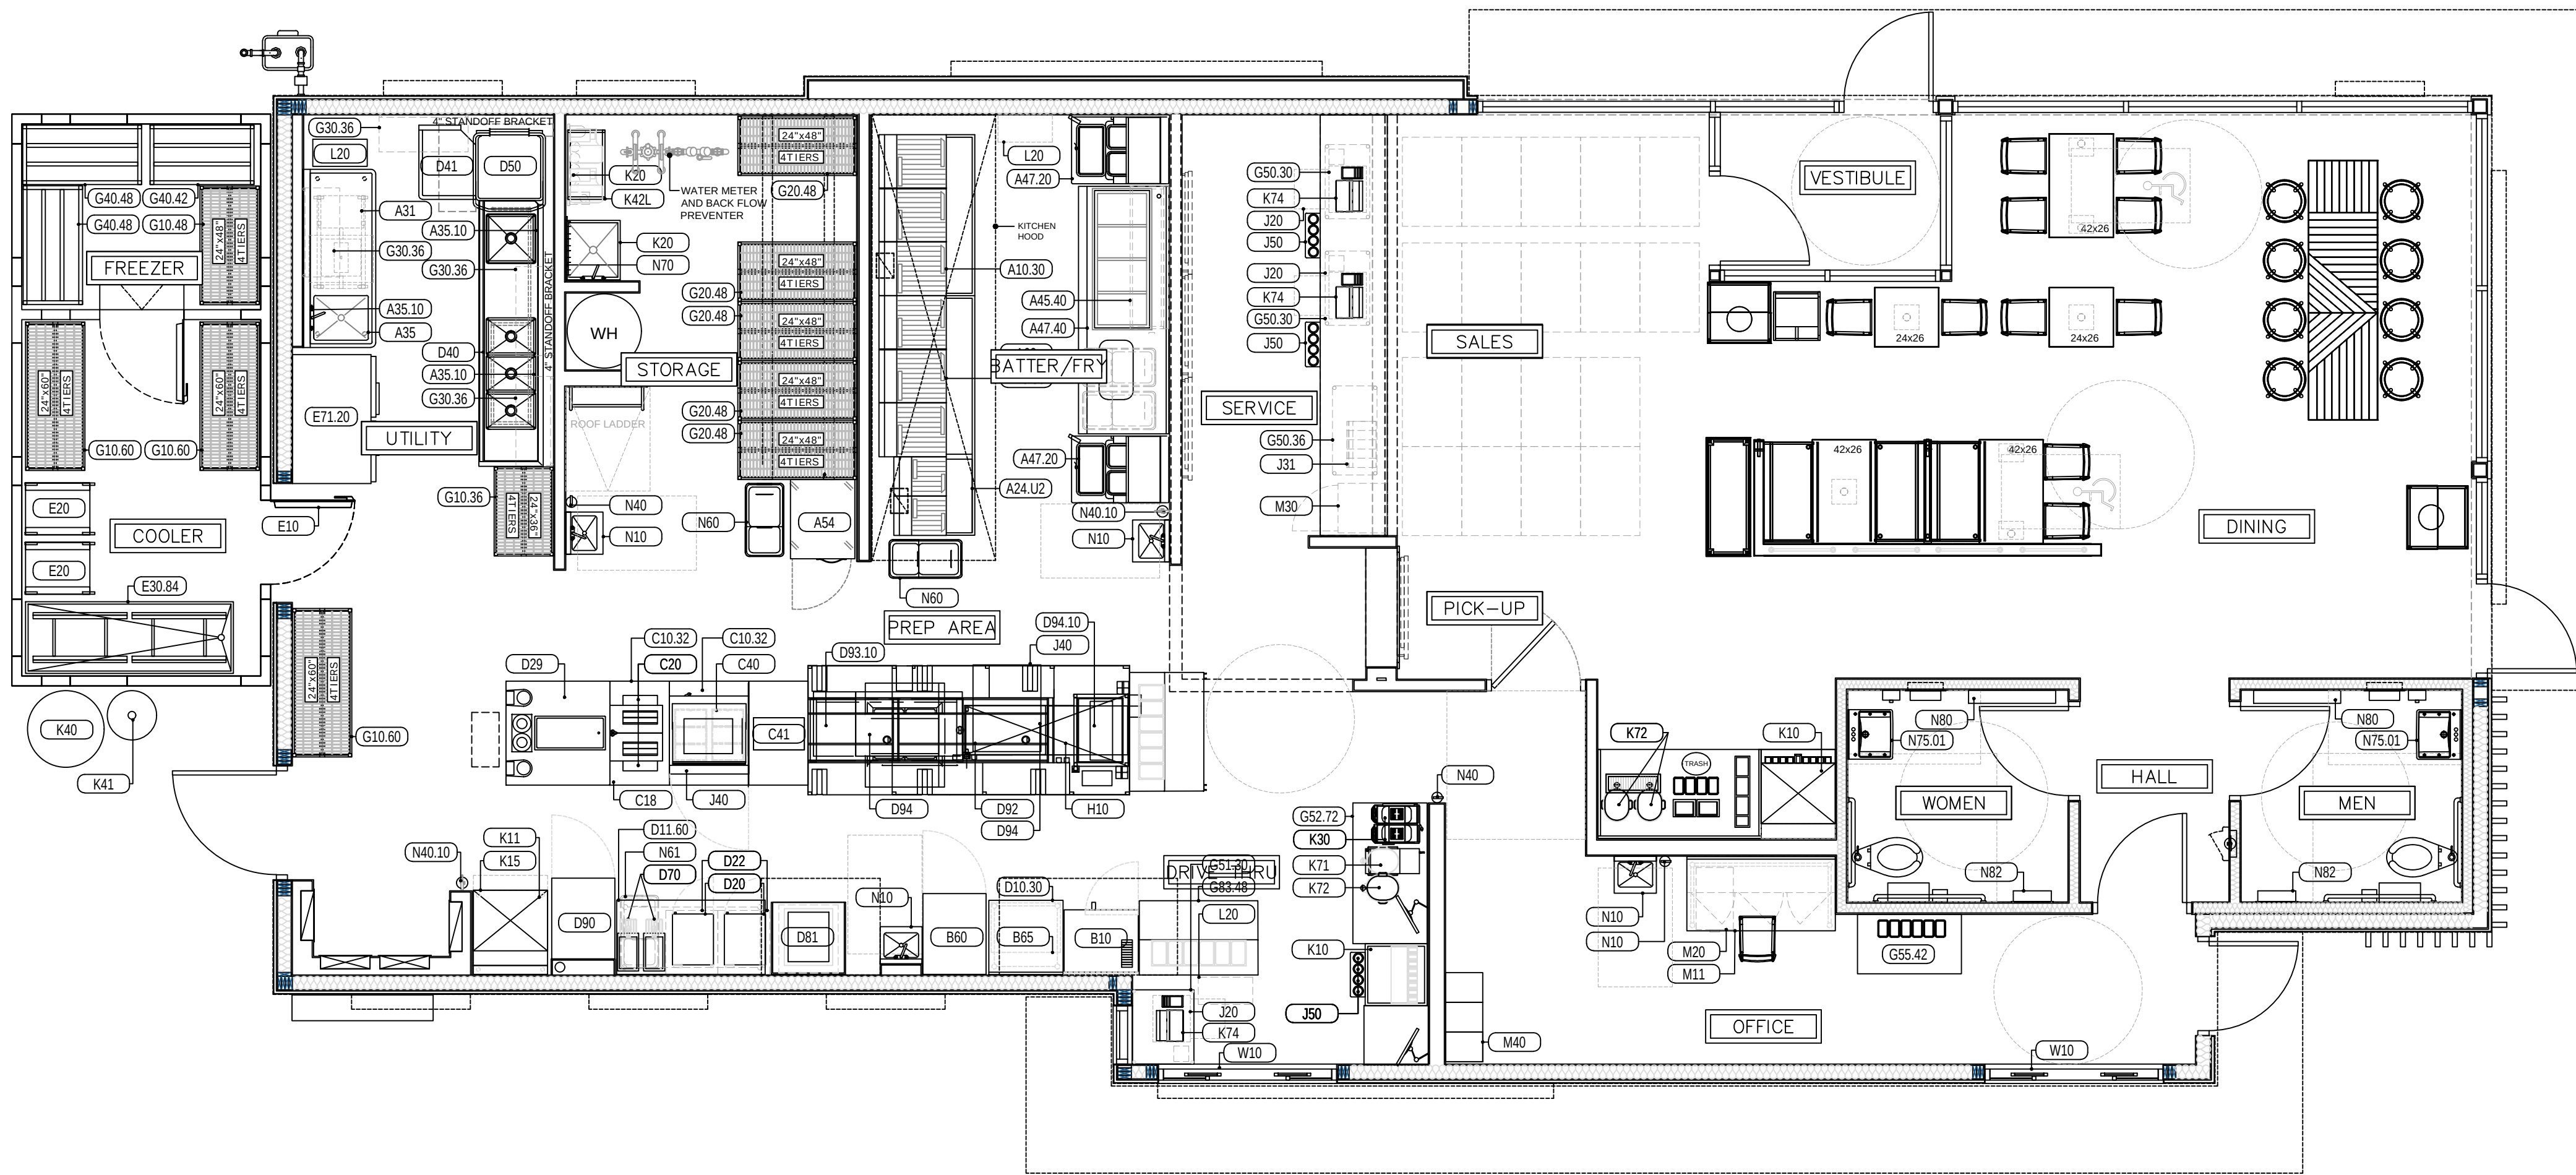

QTY.	TAG	DESCRIPTION	MANUFACTURER	MODEL	FURNISH/INSTALL	ELECTRICAL						WATER			WASTE		GAS	REMARKS			
					FURNISHED BY	INSTALLED BY	F-amps	KW	HP	VOLTS	PHASE	DIRECT	FLUO	FLTRD	COLD	HOT	DIRECT	INDIRECT	SIZE	MBTU/H	
A Fryer																					
1	A10.03	Drumroll	Arking	DRUF1201PR 8POp																	
2	A10.30	Multiple Fryer System, Gas	Ultrafryer	BP20203 8POp																	
1	A24.02	Multiple Fryer System, Gas	Ultrafryer	BP30142UCP 8POp																	
1	A31	Marinator - (reduced height)	ArKing	M101-110 8POp																	
1	A35.L	Sink, 1 Compartment	Winholt	1143828 8POp																	
1	A35.10	Pre-Rinse Faucet Assembly	T&S	B2180 8POp																	
1	A47.30	Fabrication	NWS	F423620100N																	
1	A48	3-Pan Ice Bath Table Fabrication	NWS	D576220300N																	
1	A54-R	Reach-In Freezer	Defield	GBR1P-5 8RPOp																	
1	A93.1	Grease Collection System, Interior Unit	By Owner				10.0	1.2		115	1	X									
B Baking																					
1	B10	Convention Oven, 1/2 Size, Double Deck, Elec.	Blodgett Oven	CTB DBL L8POp			(2)24	(2)6		208	3	X								0	
1	B60	Refrigerator, Upright	Defield	GBR1P-5 8RPOp			12.0		1/3	115	1	X								0	
1	B65	Biscuit Holding Unit (Option)	NWS	D.3285.30400N																	
C Sandwich																					
1	C18	Popeyes 24" x 42" Toaster Table	NWS	F775680100N																	
1	C20	Toaster	Artunes	VCT-2 8POp																	
1	C10.32	Popeyes Dual Side Sandwich Prep	NWS	F775670100N																	
1	C40	Product Holding Unit	Prince Castle	EHBP23 8POp																	
1	C41	Protein Holding Unit	Prince Castle	PHB41F 8POp			4.90		43471.00	20.00	1.00	X								0.00	
1	C50	Bun / Sheet Pan Rack	Cambro	UPR1826F20580																	
D Prep																					
1	D10.30	Work Table, w/ 4" backsplash w/ u/s	NWS	D202070400N																0	
1	D10.72	Work Table, w/ 4" backsplash w/ u/s	Kitchen Equip. Supplier	Custom																0	
2	D20	Microwave Oven	Panasonic	NE-17523 8POp			14.3	1.7		208	1	X								0	
2	D22	Shelf, Microwave Oven	NWS	D41310300N																	0
1	D29	Packing Table, Double Side	NWS	F775690100N																	0
1	D40	3 Bowl Sink	NSW	F775660100N											0.50	0.50	2.00			0	
1	D40.01	Pre-Rinse Faucet Assembly	T&S Brass	B2180 8POp											0.50	0.50	2.00			0	
1	D40.02														0.50	0.50	2.00			0	
1	D40.03	Splash Divider	NWS	F367400100N											0.50	0.50	2.00			0	
1	D41	Clean Dishtable	Advance Tabco	DTC-S60-24R											0.50	0.50	2.00			0	
1	D50	Dishwasher	Hobart	AM-15VLT-2 8POp											0.50	0.50	2.00			0	
2	D70	Dispenser, Hot Water w/Wall Bracket	Burn-O-Matic	H5SL 8POp											0.50	0.50	2.00			0	
1	D81	Chubb Warmer, Elec. Re thermometer	Ultrafryer Systems	REC-1620-X 8POp			47.6	9.5		208	1	X			0.25			1.50		0	
1	D90	Proofer Cabinet, Mobile	Winston	HA5522 8RPOp			17.6	2.11		120	1	X								0	
1	D92	Side Items Holding Unit, Pass-Thru	Prince Castle	PHB21N2 8POp																	
1	D93.1	Holding Bins	Prince Castle	DHB2PT-60P 8POp			54.75	3.68		120/208	3.00	X									Verify Utilities
1	D94	Protein Holding Bin	Prince Castle	PHB34R2 8POp																	
1	D94.10	Biscuit Holding Bin	Prince Castle	PHB21N1 8POp																	
E Walk-In																					
1	E10.1	Walk-In Cooler	Kolpak	Custom						208	3	X								0	Verify Dimension & Utilities with K.E.S.
1	E10.2	Walk-In Freezer	Kolpak	Custom						208	3	X								0	Verify Dimension & Utilities with K.E.S.
2	E20	Chicken Rack	SPG	4H1286 8POp																	
1	E30.84	Chicken Crate	NWS	D125050500N																	
1	E71	Even-Thaw Refrigerator	Traulsen	RE232N-1 8POp																	
F Ventilation																					
1	F15.1	Heated, Holding Unit, Wall mount	Kitchen Equip. Supplier	Custom (PC-HPL52-26)			18.8	3.9		208	1	X								0	
G Shelving																					
5	G20.36	Wire Shelving, 4Tier, 24" Wide, 36" Long	Metro	2436N3 8POp																	
11	G20.48	Wire Shelving, 4Tier, 24" Wide, 48" Long	Metro	2448N3 8POp																	
1	G21.36	Wire Shelving, 4Tier, 18" Wide, 36" Long	Metro	Custom																	
4	G30.36	Shelving, 2 Tier Wall Mounted, 42" Long	Metro	1436N3																	0
5	G30.42	Shelving, 2 Tier Wall Mounted, 42" Long	Metro	1448N3 8POp																	0
1	G40.42	Dunnage Rack, 24" Wide x 42" Long	NWS	DUN240836																	0
2	G40.48	Dunnage Rack, 24" Wide x 48" Long	NWS	DUN240848																	0
1	G51.36	Pos Table	Metro																		0
2	G61.30	Wire Shelving, 2 Tier, Undercounter w/ 34" Posts, 18"x30"	Metro	1830BR 8POp																	0
1	G61.36	Wire Shelving, 2 Tier, Undercounter w/ 36" Posts, 18"x36"	Metro	1836BR 8POp																	0
1	G61.42	Wire Shelving, 2 Tier, Undercounter w/ 42" Posts, 18"x42"	Metro																		0
1	G55.42	Work Table w/ Under Shelf	NWS	D092820300N																	0
1	G83.48	Expedite Table	NWS	F775720100N																	0

QTY	TAG	DESCRIPTION	MANUFACTURER	MODEL	FURNISH/INSTALL					ELECTRICAL					WATER		WASTE		GAS		REMARKS
					FURNISHED BY	INSTALLED BY	FL-mps	KW	HP	VOLTS	PHASE	DIRECT	PLUG	FILTERED	COLD	HOT	DIRECT	INDIRECT	SIZE	METH	
1	P52.66	Drive-Thru Drink Station Production	NWS	F234440200N																	
1	H10	Modular Dual Line	NWS	F775280200N			14.0	3.5		120/208	0.3X				0.50		2.00			0	Verify Dimension & Utilities with K.E.S.
2	H83	Window-Wide open, Drive-Thru, Automatic J Front Service					15.0			120	1 X									0	
3	J20	Cash Controller	NKL Industries	W-101																0	
1	J31	Suspended Condiment Holder	Combo	129512 BPQP																0	
1	J40	Refrigerator, Undercounter	Silver King	SKRS28-RS BPQP			4.9		1/6	120	1	X								0	
1	J41	Refrigerator, Undercounter	Silver King	SKRS28-RS BPQP			4.9		1/6	120	1	X								0	
1	J50	Disposable Cup Dispenser	DISPENSE-RITE	WR--CC--22-PQP																0	
2	J51	Disposable Cup Dispenser	DISPENSE-RITE	WR--CC--22-PQP																0	
	K	Drinks																			
3	K10F	Ice Maker, Cube-Style	Manitowoc	IBF0620C			11.9	6.7	1 1/2	208-230	1	X			.375			0.5		0	Remote Condenser Model JC--0895
3	K11	Ice Maker, Cube-Style	Manitowoc	1TF09A00N_8PQP			11.9	6.7	1 1/2	208-230	1	X			.375			0.5		0	Remote Condenser Model JC--0895
1	K15	Ice Bin, 570 lbs	Manitowoc	B570_8PQP											.75					0	
1	K20	Water Filter, Equipment	Ewarpure	EV94370_8PQP																0	
2	K30	Drink Machine	BUNN	34000.0012			1.5			115	1	X			.375			0.75		0	
3	K32	Soda Dispenser, 8 Heads, Counter w/ Ice Bin, Adapter Plate	Lancor	IBD4500			1.5			115	1	X			.375			0.75		0	
1	K40	C02 Tank, Bulk	Airgas	Carbo-Mizer 450																0	
1	K42L	Bag-N-Box Rack / w 2 Carbonators on Shelves (Legacy)	McCann's	2-CI44239 15-2902(28x16x74)			7.2		1/3	115	1	X								0	
2	K71	Brewer, Tea & Coffee	Bunn-O-Matic	TB300113 BPQP			14.0	1.7		120	1	X			0					0	
4	K72	Tea Dispenser, Urn, Solid Lid	Bunn-O-Matic	T0040_8PQP																0	
1	K74	KDS Dining	Custom	Custom			7.2		1/3	115	1	X								0	
	L																				
1	LP50	Self-Serve Beverage Counter	Seating Vendor	Custom																0	
1	LP52	Condiment Holder, 17.5 Size Ports	Continental Carisle	1/9th Pan																	
1	LP54	Stainless Steel Drip Pan	Kitchen Equip. Supplier	Custom																	
2	LP56	Dispenser, Napkin, Drop-In	San Jama	H2001CLSS																0	
1	LP58	Lid & Straw Holder	Seating Vendor	Custom																	
	M	Office																			
1	LP10	Chair, Dining	Seating Vendor	Custom								1	X							0	
1	M11	Managers Desk	NWS	F367310100N						120		1	X							0	

David L. Givens


CT	13585
DE	S5-0008497
DC	AEC103027
MA	951753
MD	18745
NJ	AI 15475
NH	04842
NY	03933C
OH	ARC.201821C
PA	AR07639
VA	0401019058



POPEYES LOUISIANNA KITCHEN
470 EAGLE ROCK AVE.
WEST ORANGE - NJ

PROPOSED EQUIPMENT PLAN

 Revisions




Drawn By MHS	Checked By RAG
Scale AS NOTED	Date 2021-11-10

Job No. 01 0000

21-0032

THIS DRAWING IS COPYRIGHTED AND PROTECTED UNDER THE LAWS OF THE UNITED STATES OF AMERICA. ANY UNAUTHORIZED USE OR REPRODUCTION OF THIS DOCUMENT WITHOUT WRITTEN CONSENT OF ROBERT A. GRIMALDI IS AN INFRINGEMENT UPON COPYRIGHT LAWS. VIOLATORS WILL BE SUBJECT TO PROSECUTION BY THE FULL EXTENT OF THE LAW.

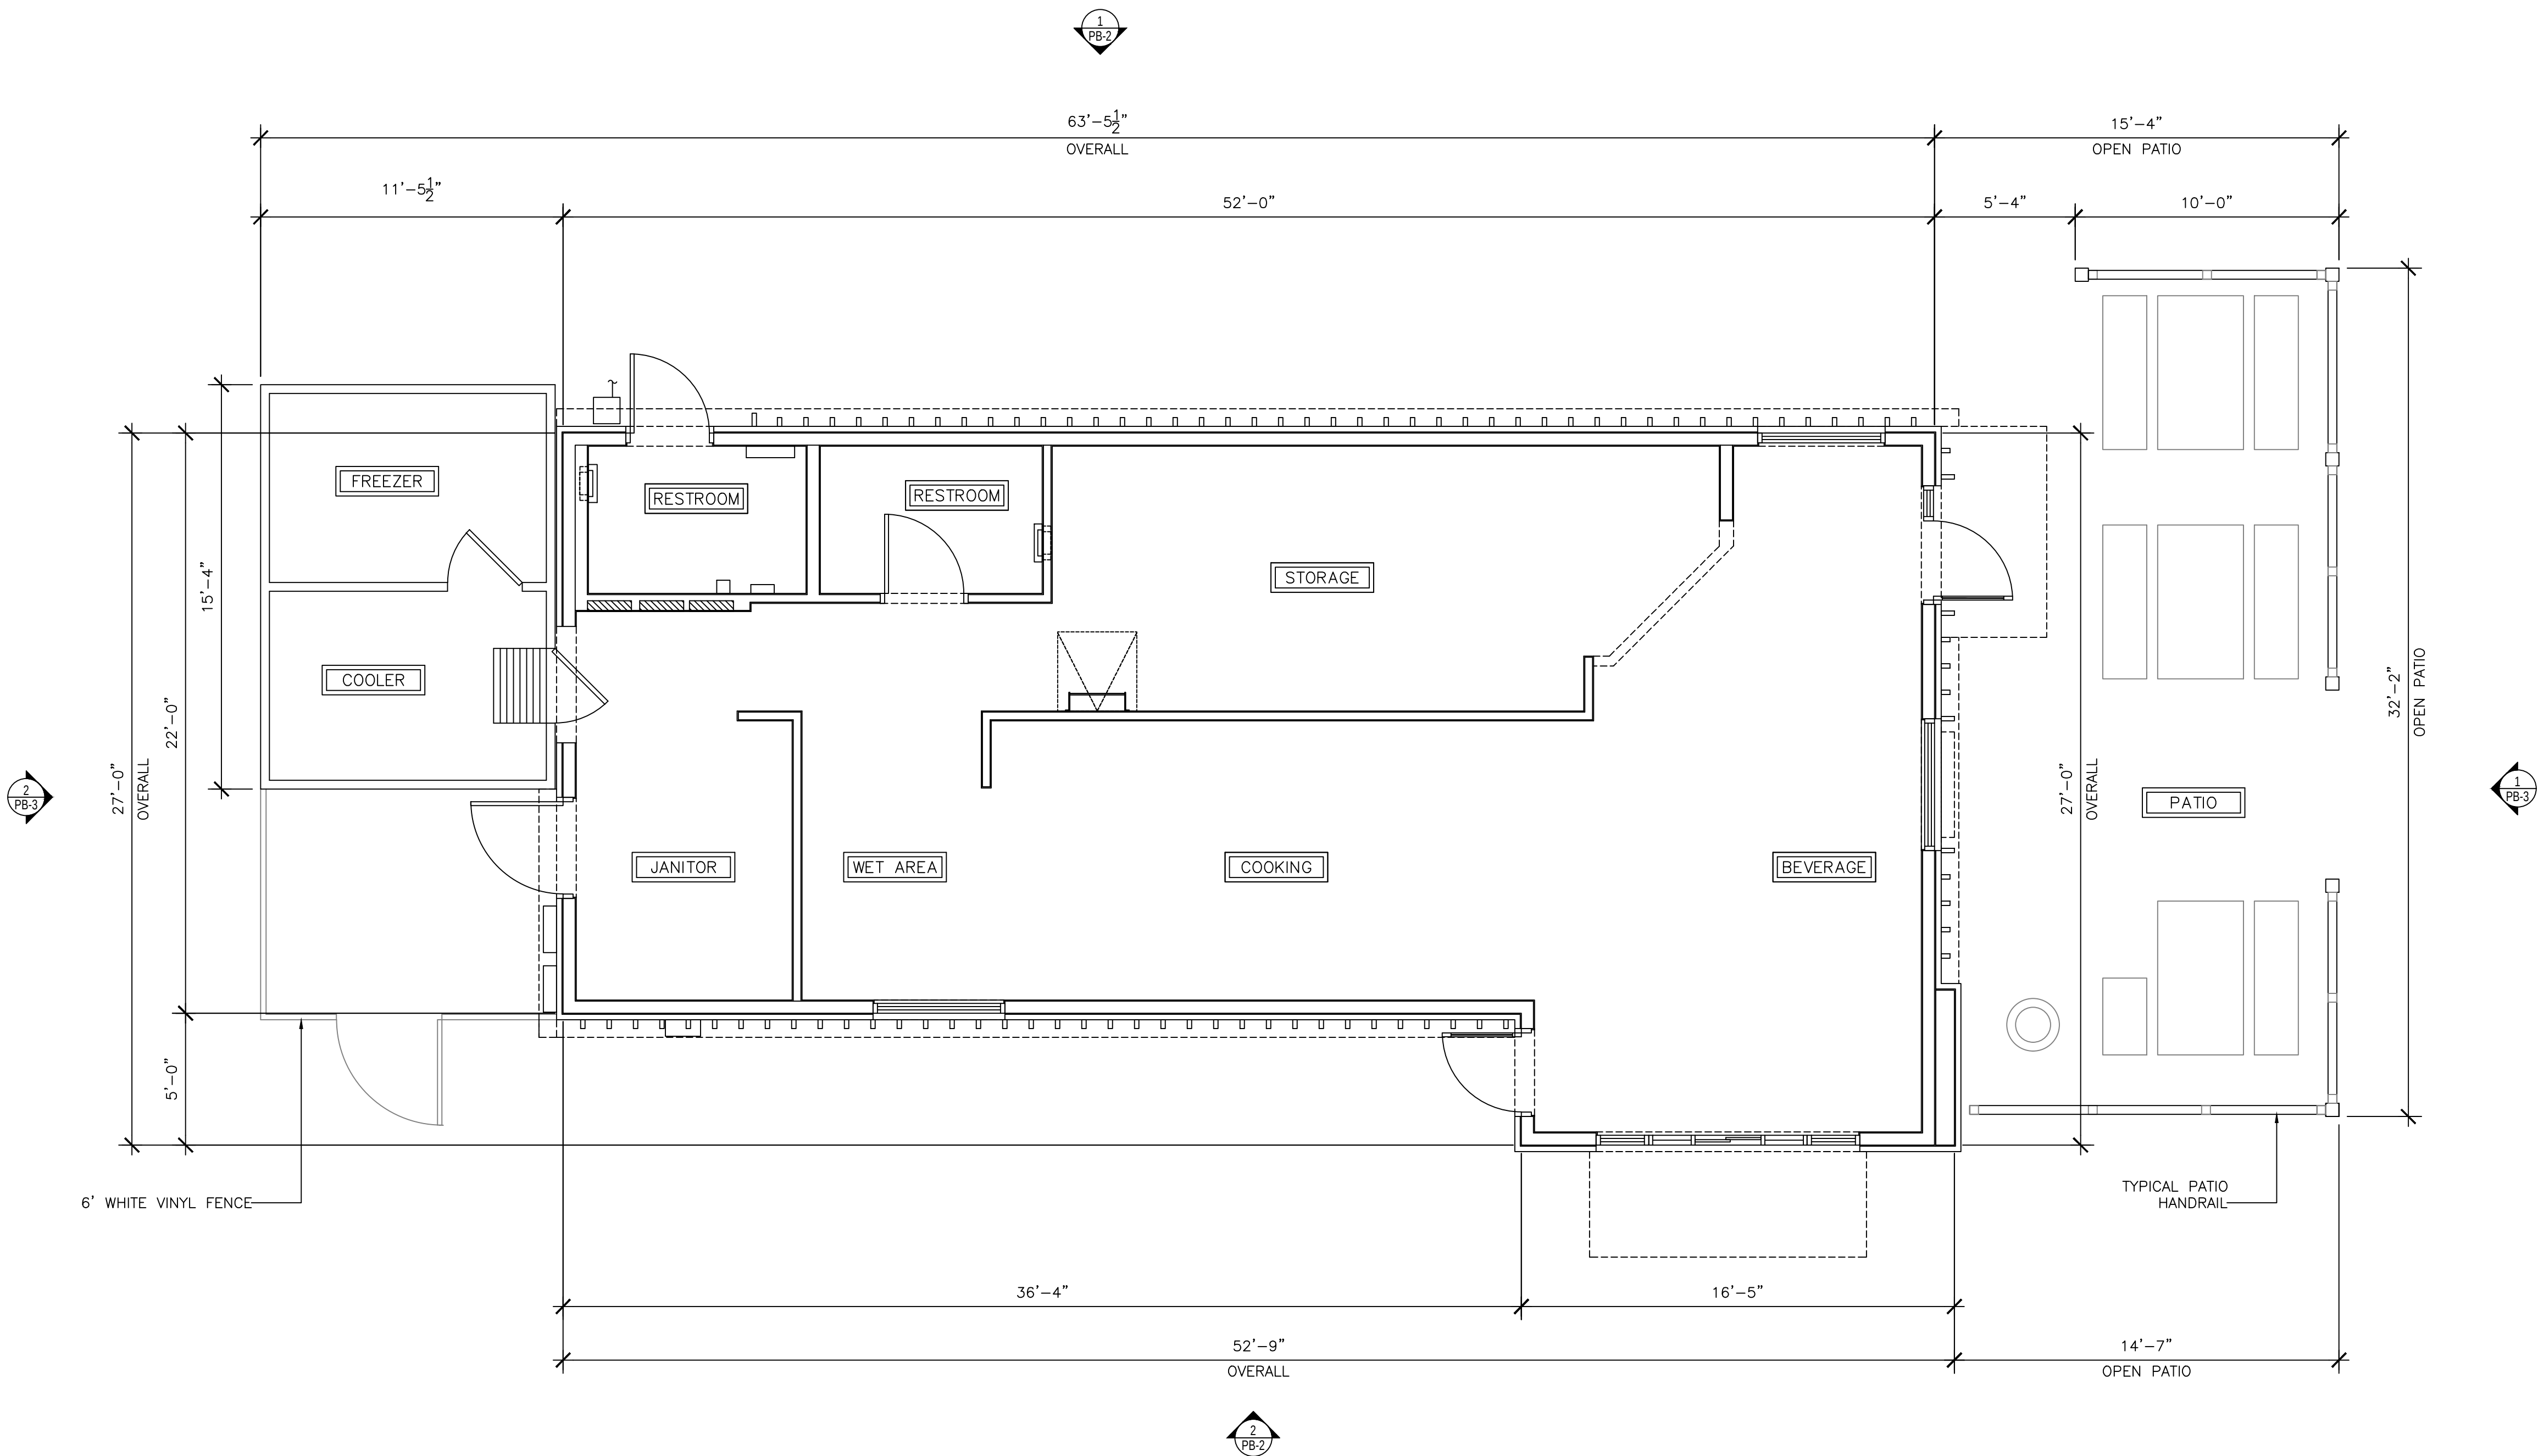

1
PB-1

PROPOSED FLOOR PLAN

1/4" = 1'-0"


BUILDING AREA CALCULATIONS

BUILDING AREA (GROSS): 1,267 SF
BUILDING AREA (NET): 1,066 SF

EXTERIOR AREA
WALKING COOLER/FREEZER: 171 SF
EXTERIOR DINING AREA: 433 SF
EXTERIOR RESTROOM: 46 SF
TOTAL EXTERIOR AREA: 650 SF

18 OUT DOOR CUSTOMERS SEATS

G 141 ARCHITECTURE, LLC

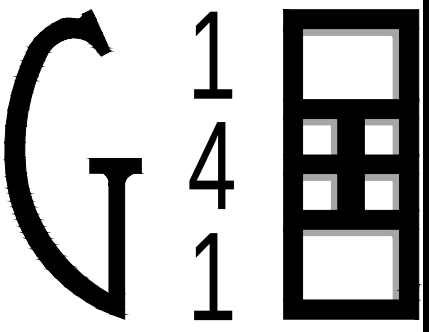


ARCHITECTURE, LLC

ROBERT ANTHONY GRIMALDI
39 NORTH 11th STREET
KENILWORTH, NJ 07033
g141office@gmail.com
908-347-7419

NCARB 84690
AIA 38640695

CT 13585
DE S5-0008497
DC AEC103027
MA 951751
MD 18745
NJ AI 15475
NH 04842
NY 039330
OH ARC.2018210
PA AR07639
VA 0401019058

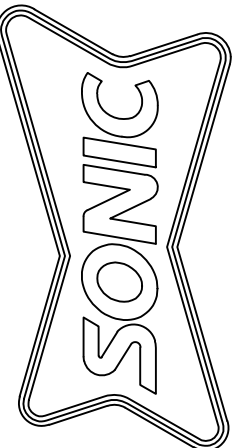

SONIC DRIVE-IN RESTAURANT
470 EALGE ROCK AVE
WEST ORANGE, NJ - 07052

352326(')/225 3/\$1
23(1 3\$7,2 9(56,21

SHYLVLRQV

△:
△:
△:
△:
△:

Drawn By MC Checked By RAG


Scale AS NOTED Date 2023-05-04

Job No.

23-0027

Sheet No.

PB-1

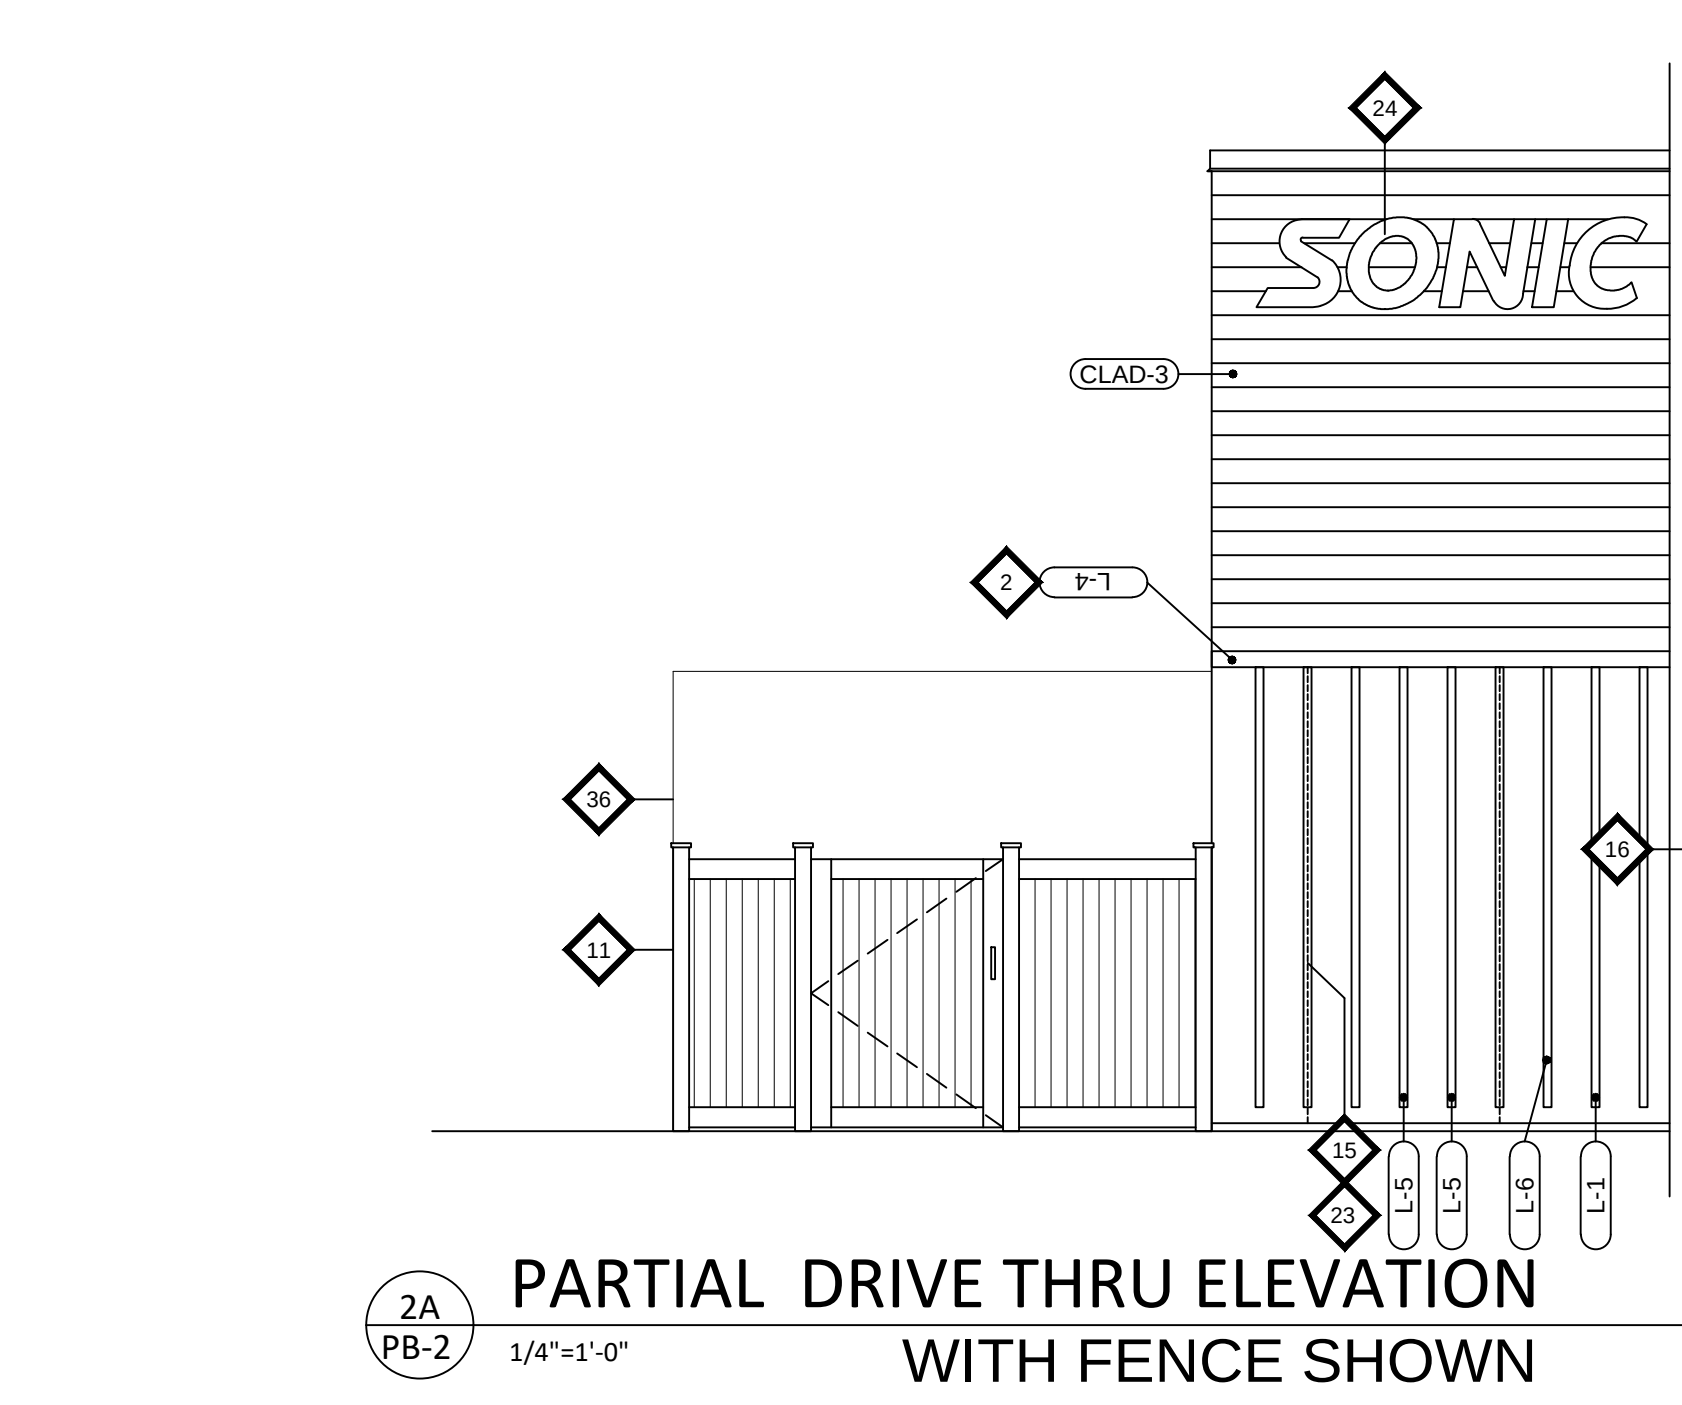

GENERAL NOTES


- DIMENSIONS OF REVEALS ARE TO CENTERLINE - VERIFY GRADE PRIOR TO CONSTRUCTION
- DO NOT SCALE DRAWINGS - CONTACT ARCHITECT FOR ANY DISCREPANCIES ARE FOUND
- REFER TO CANOPY DRAWINGS FOR ADDITIONAL PREMANUFACTURED CANOPY INFORMATION

SONIC DRIVE-IN RESTAURANT
470 EALGE ROCK AVE
WEST ORANGE, NJ - 07052


PROPOSED EXTERIOR ELEVATION
OPEN PATIO VERSION

Revisions	
△ : △ : △ : △ : △ :	
Drawn By MC	Checked By RAG
Scale AS NOTED	Date 2023-05-04
Job No. 23-0027	
Sheet No. PB-2	


THIS DRAWING IS COPYRIGHTED AND PROTECTED UNDER THE LAWS OF THE UNITED STATES OF AMERICA. ANY UNAUTHORIZED USE OR REPRODUCTION OF THIS DOCUMENT WITHOUT WRITTEN CONSENT OF ROBERT A. GRIMALDI IS AN INFRINGEMENT UPON COPYRIGHT LAWS. VIOLATORS WILL BE SUBJECT TO PROSECUTION BY THE FULL EXTENT OF THE LAW.

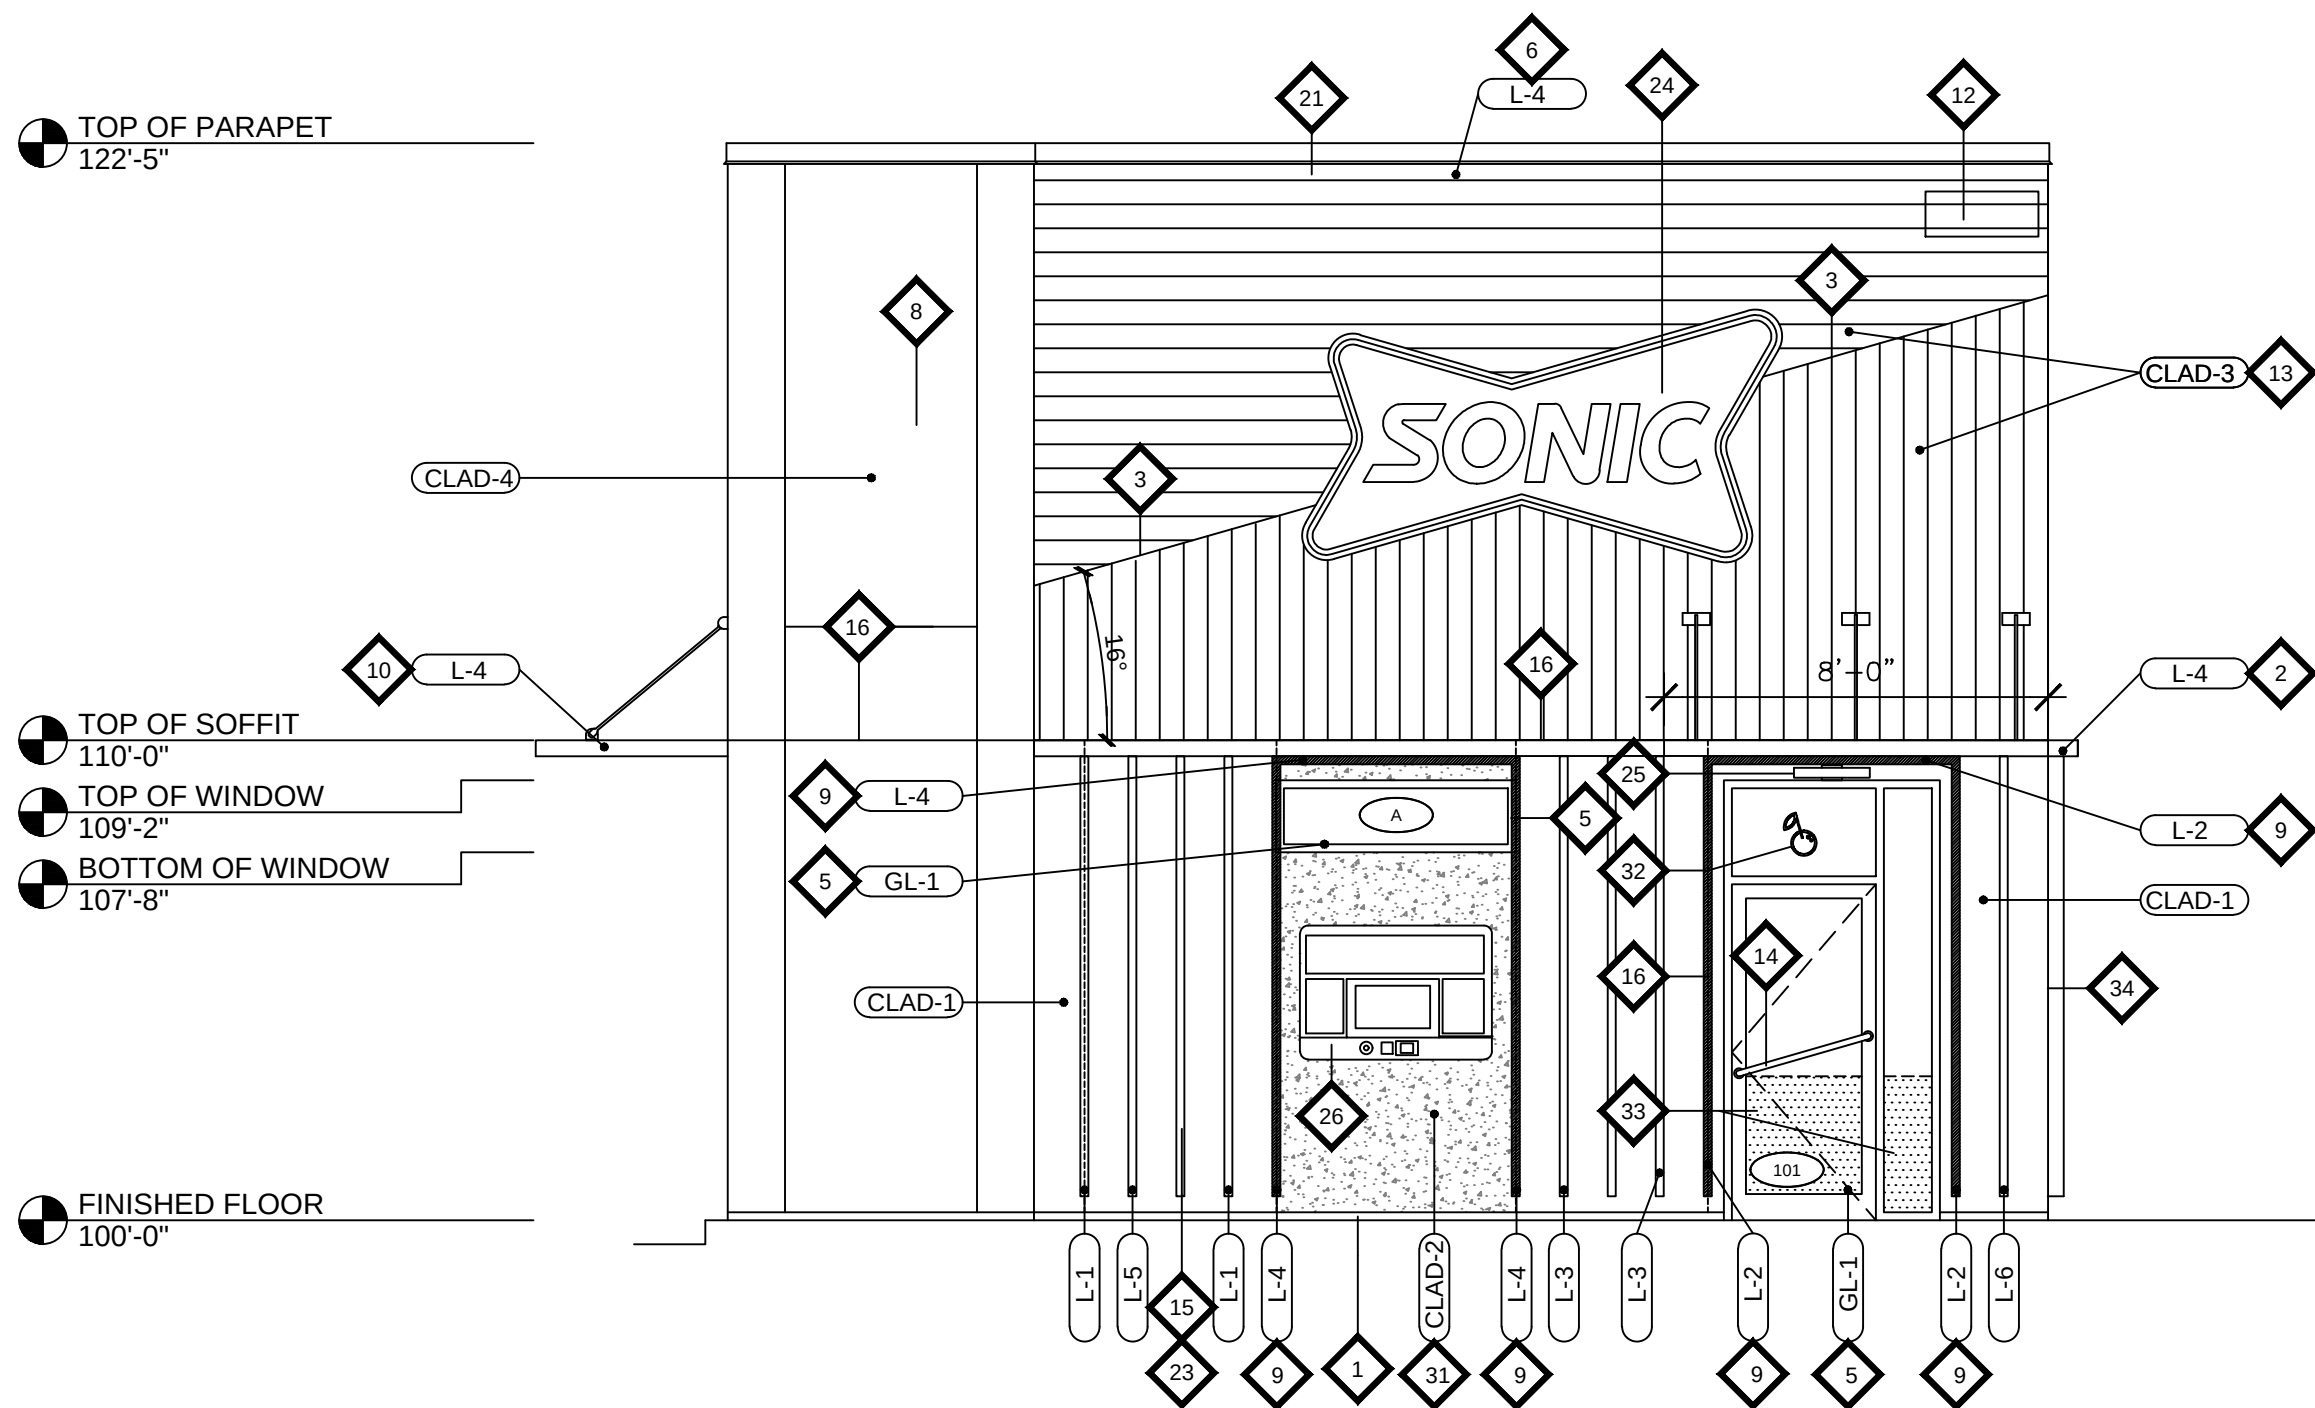


1
PB-3
1/4"=1'-0"
PROPOSED FRONT ELEVATION
WITHOUT PATIO SHOWN

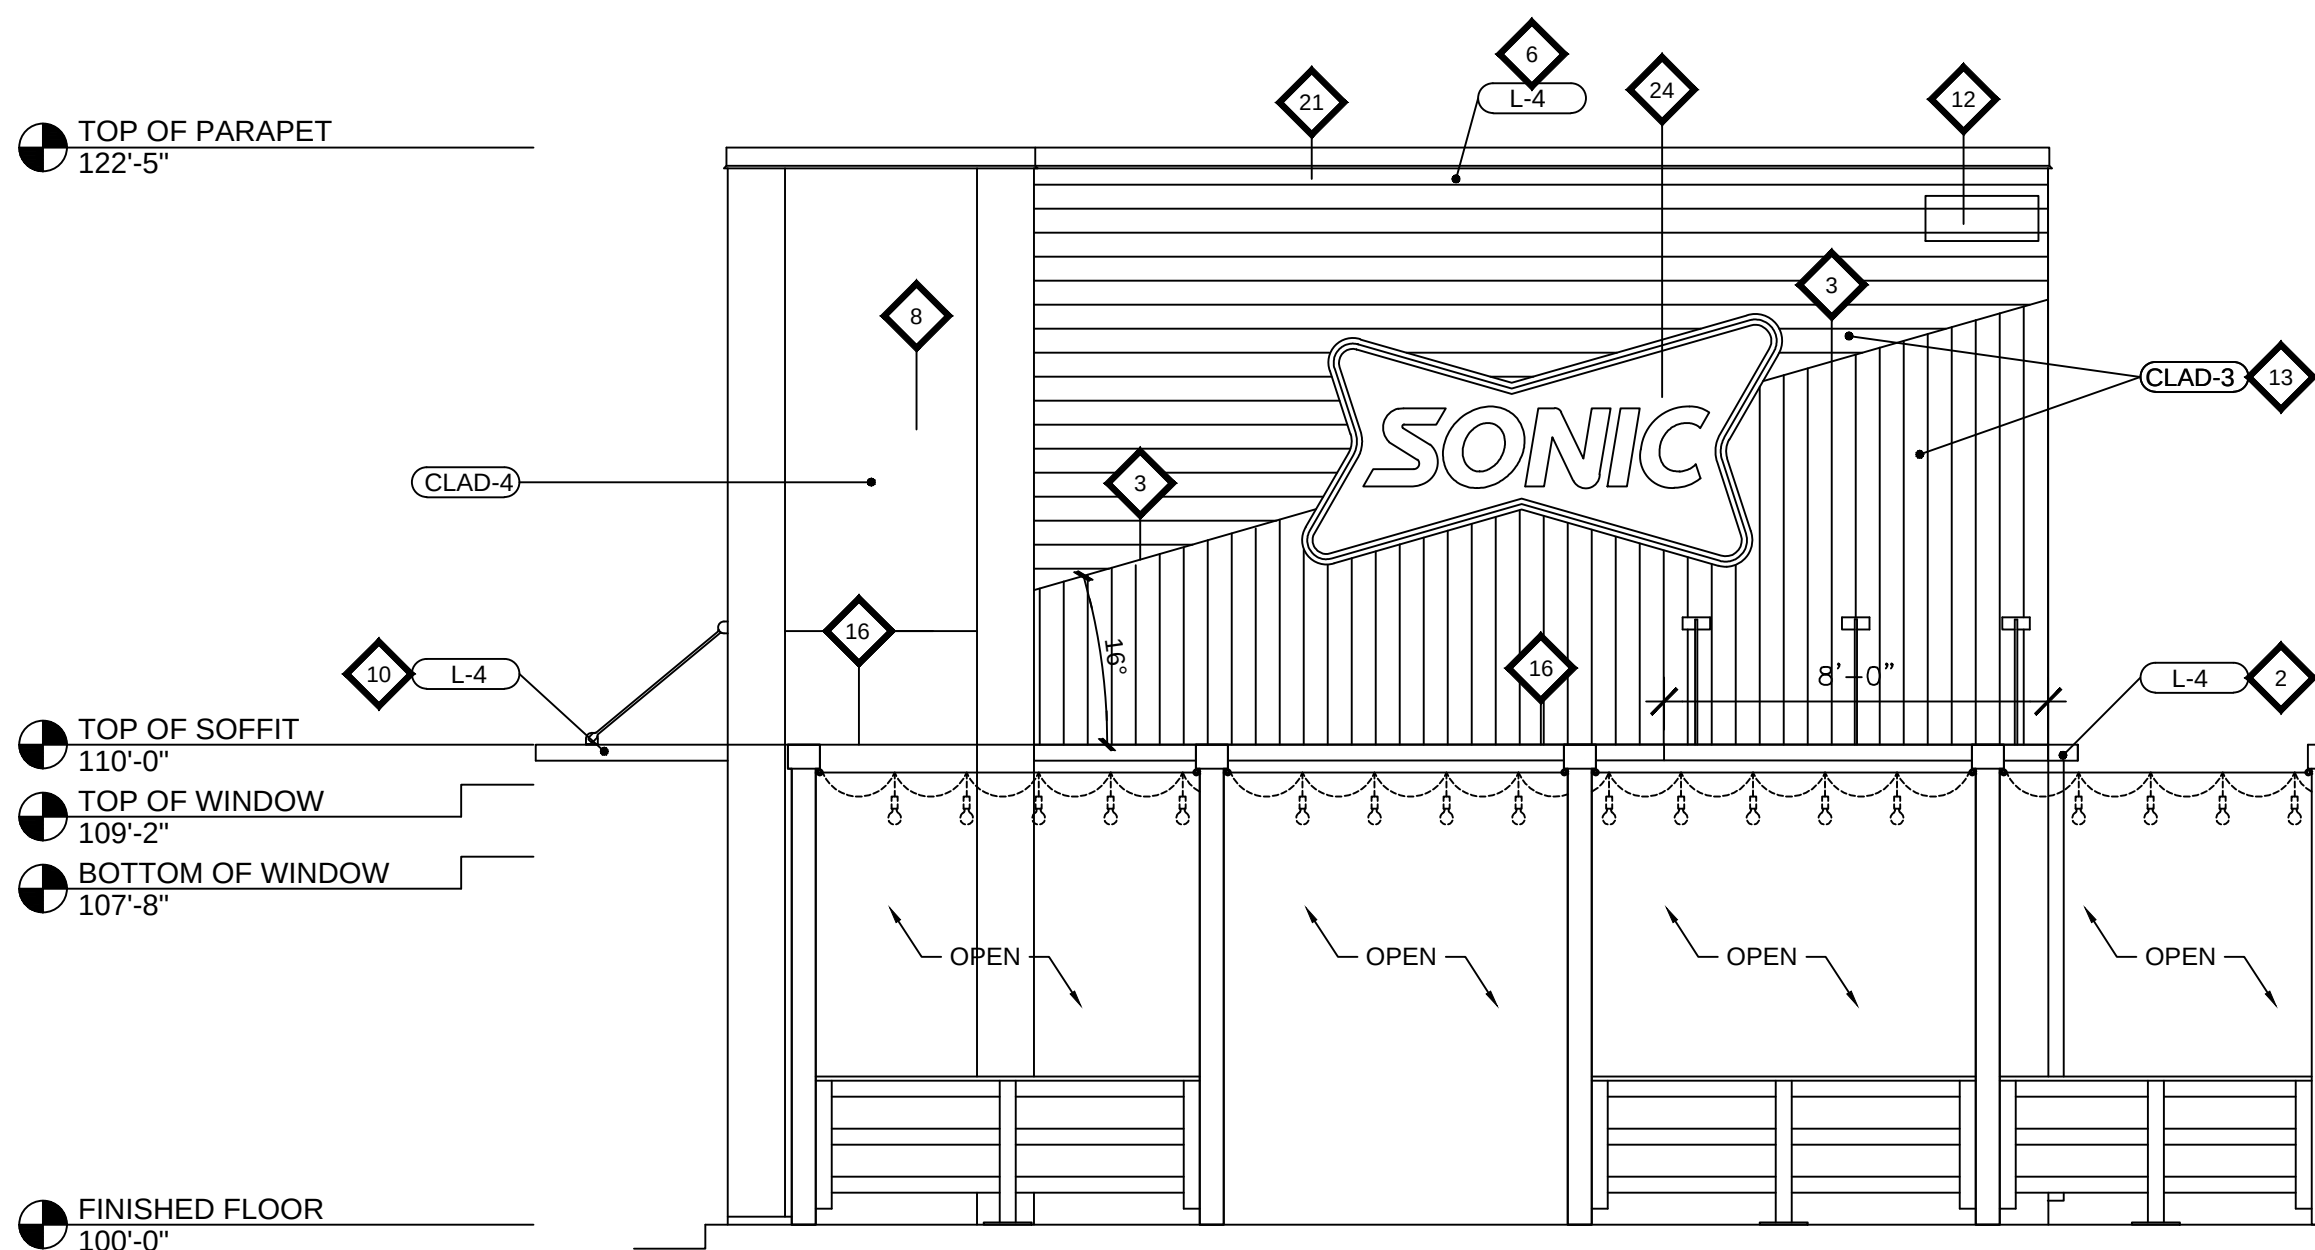

1A
PB-3
1/4"=1'-0"
PROPOSED FRONT ELEVATION
WITH PATIO SHOWN

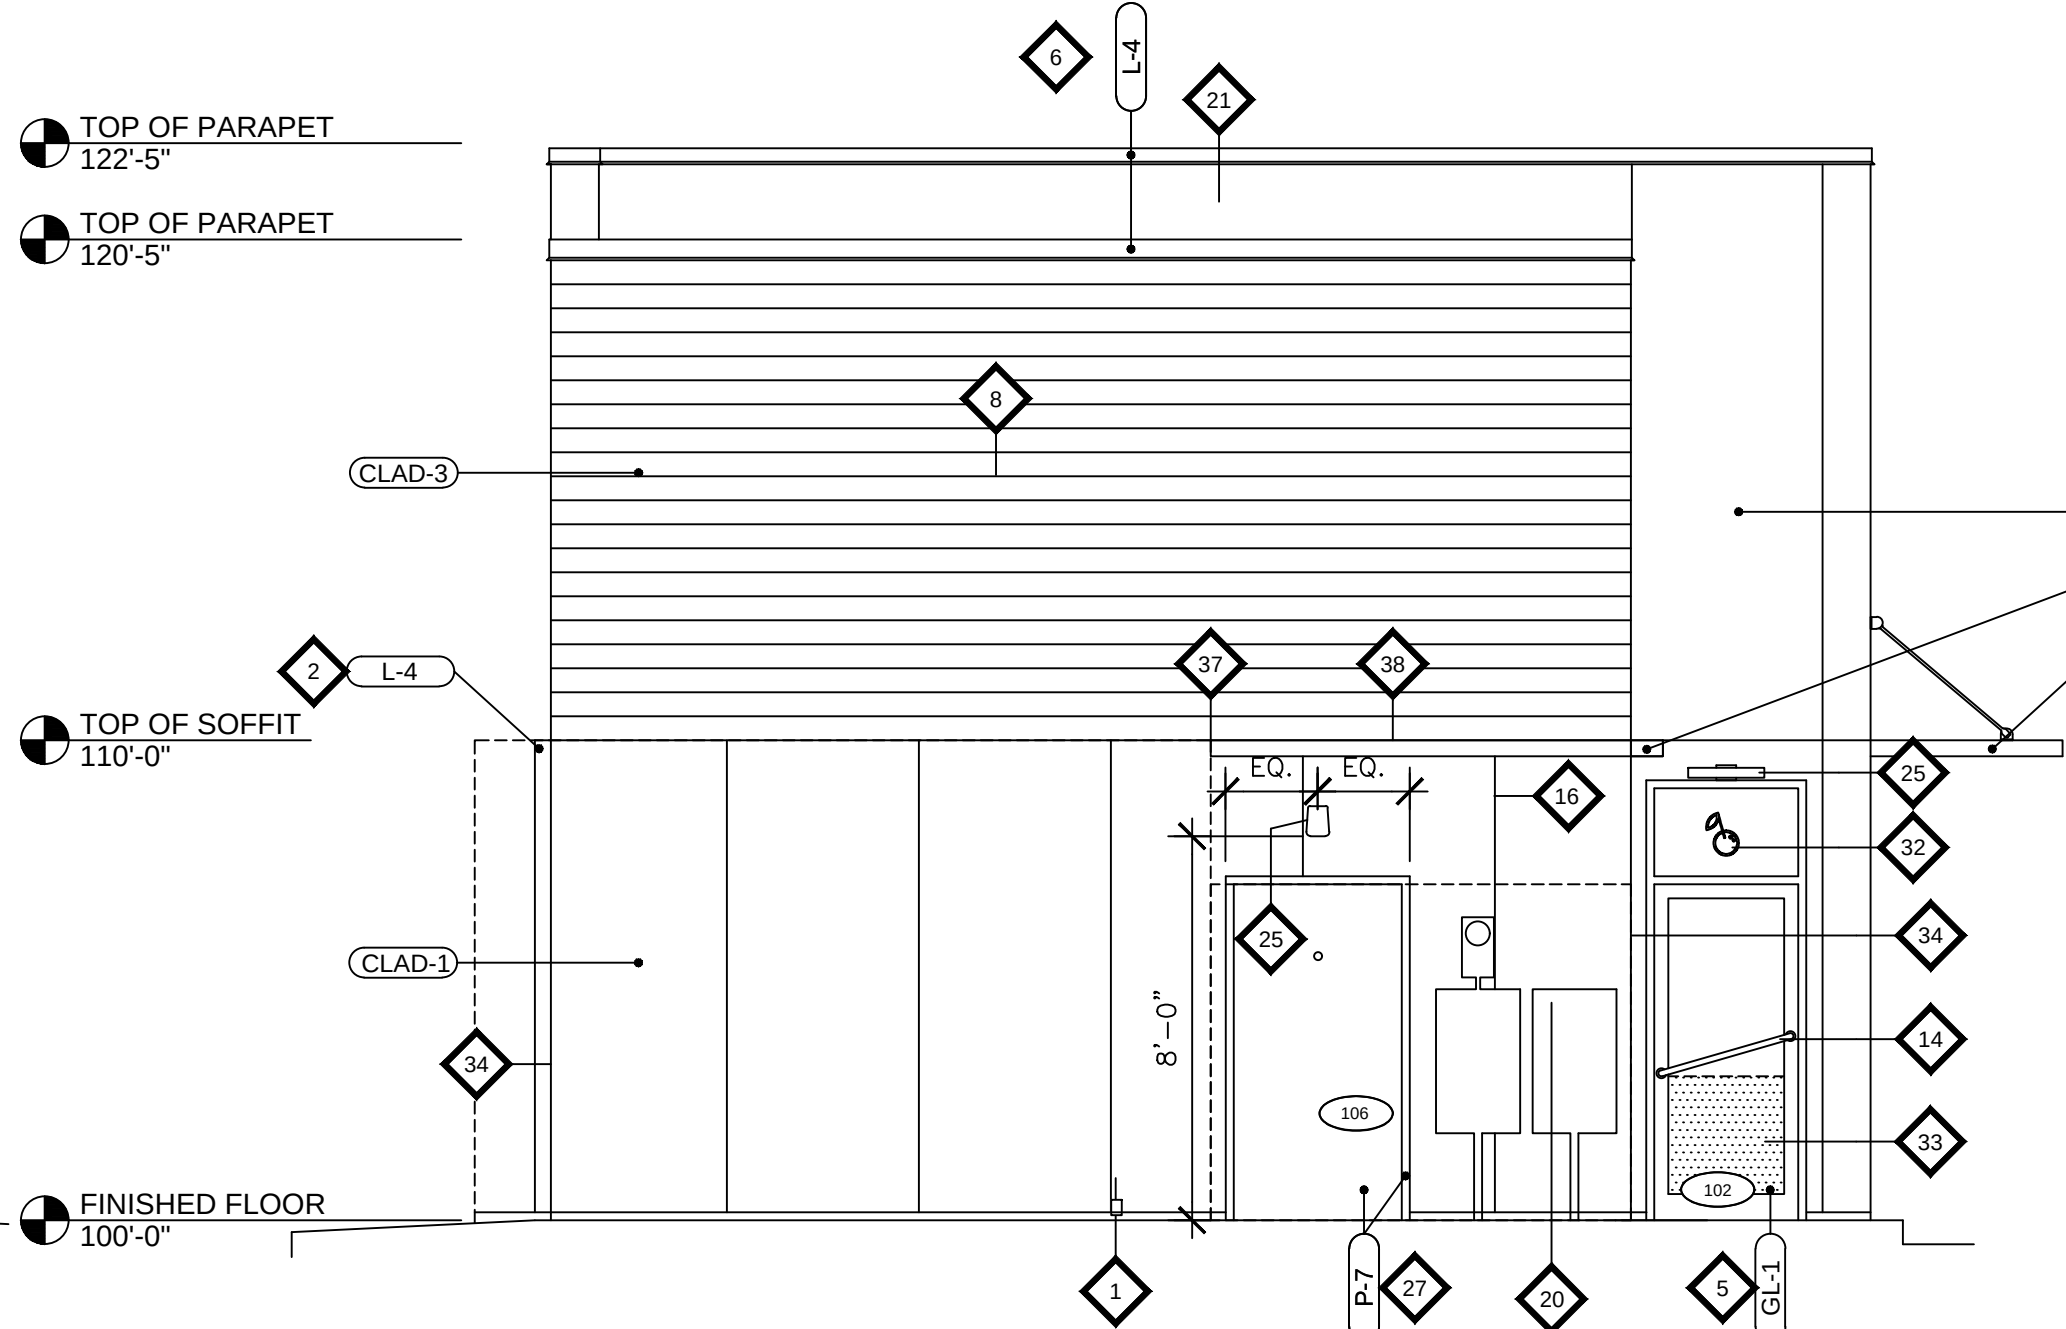

2
PB-3
1/4"=1'-0"
PROPOSED REAR ELEVATION
WITHOUT COOLER & FENCE SHOWN

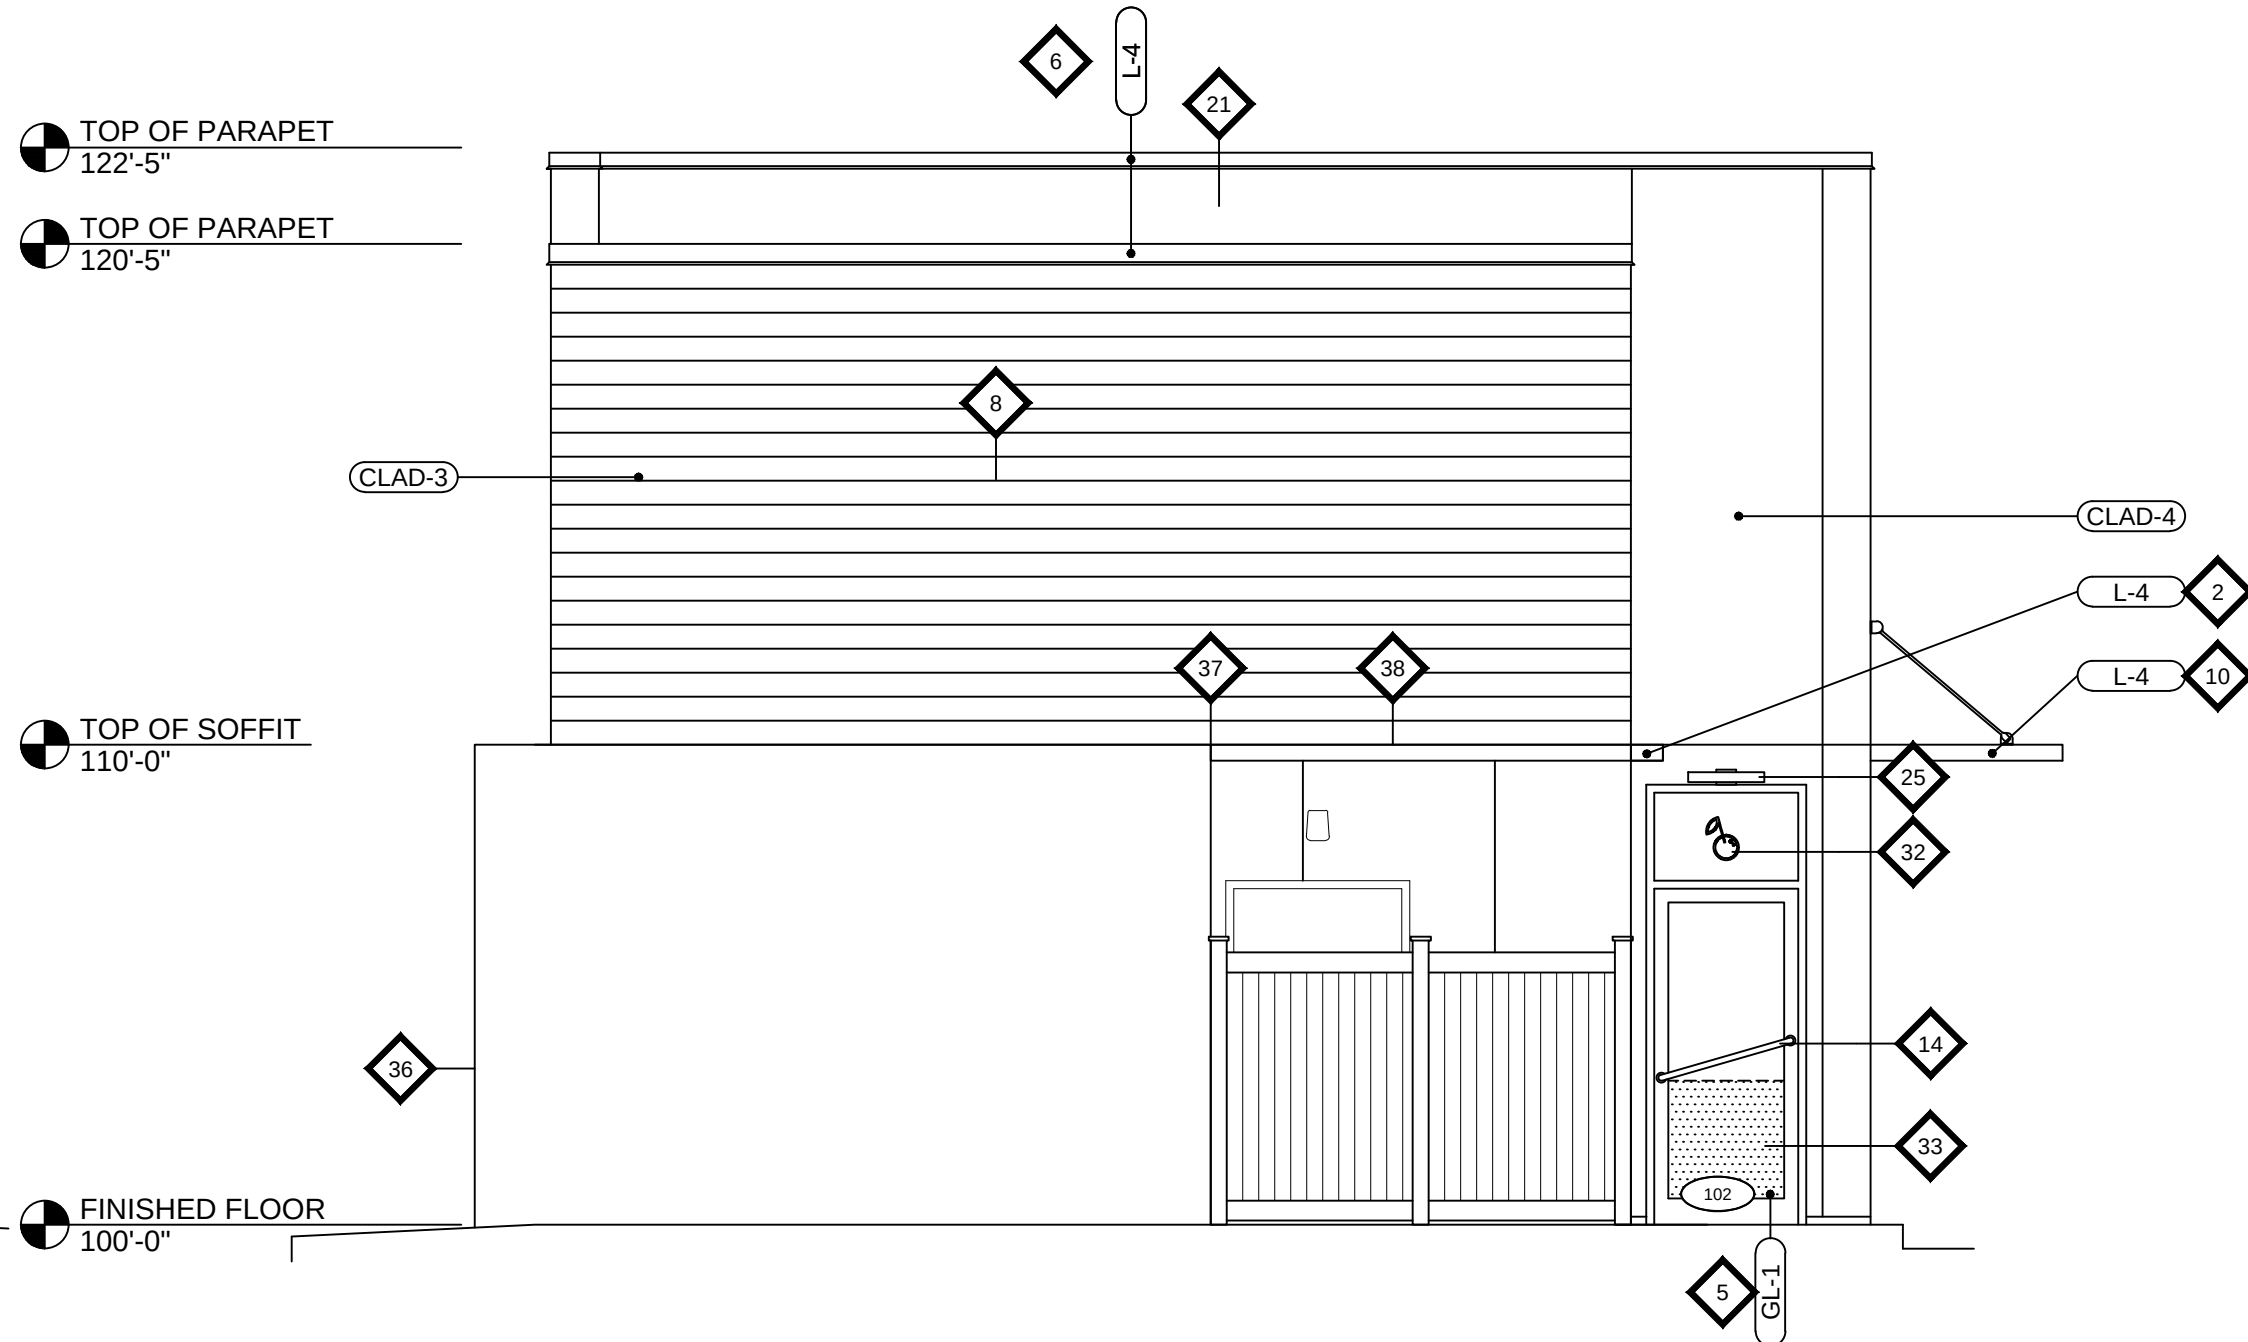

2A
PB-3
1/4"=1'-0"
PROPOSED REAR ELEVATION
WITH COOLER & FENCE SHOWN

DRAWING LEGEND

KEYED NOTES

- | | |
|---|--|
| 1 2" EXPOSED CONCRETE CURB, TYPICAL | 22 NOT USED |
| 2 4"X8" PRE-MANUFACTURED ALUMINUM EYEBROW / SOFFIT | 23 2"X4" BATTEN / LENTICULAR - PAINTED L-4 UNLESS OTHERWISE NOTED. REFER TO 10/A5.01 |
| 3 3/4" T MOLDING | 24 AVAILABLE SIGN LOCATION AS DETERMINED BY OWNER PER LOCAL SIGN ORDINANCES. SIGNS BY APPROVED SIGN COMPANY. GENERAL CONTRACTOR TO PROVIDE ELECTRICAL. SIGNAGE IS NOT APPROVED WITH THIS DEVELOPMENT PLAN. A SEPARATE COORDINATED SIGN PLAN (CSP) IS REQUIRED. |
| 4 NOT USED | 25 DOWN LIGHT FIXTURE <ul style="list-style-type: none">REFER TO ELECTRICAL DRAWINGSPROVIDE BACKING AS NECESSARYREFER TO DIMENSION FOR MOUNTING HEIGHT |
| 5 ALUMINUM STOREFRONT DOORS AND WINDOW FRAMES | 26 PATIO ORDER MENU BOARD TO BE WALL MOUNTED - 39" A.F.F. TO PUSH/CALL BUTTON |
| 6 CAP FLASHING - REFER TO 9/A5.01 | 27 HOLLOW METAL DOOR AND FRAME |
| 7 ADDITIONAL PAY STATION - REFER TO ELECTRICAL FOR ADDITIONAL INFORMATION | 28 POWER FOR STRING LIGHTS @ 9'-6" AFF. COORDINATE LOCATION WITH ELECTRICAL DRAWINGS |
| 8 DASHED LINE INDICATES ROOF LINE BEYOND | 29 RESTROOM SIGNAGE (YELLOW) - BY SIGN COMPANY - GENERAL CONTRACTOR TO INSTALL |
| 9 2"X6" POWDER COATED ALUMINUM SURROUND | 30 HATCH REPRESENTS BURGER AND SHAKE PRINT ON CLAD-2 |
| 10 PRE-MANUFACTURED ALUMINUM CANOPY - REFER TO 13/A5.01 | 31 HATCH REPRESENTS CONCRETE PRINT ON CLAD-3 |
| 11 WHITE VINYL FACE | 32 CHERRY GRAPHIC WINDOW FILM |
| 12 ADDRESS NUMBERS PER LOCAL FIRE DEPARTMENT / AUTHORITY - PROVIDED AND INSTALLED BY GENERAL CONTRACTOR | 33 DOT GRAPHIC WINDOW FILM |
| 13 FINISHED FACES TO ALIGN | 34 OUTSIDE CORNERS AT FLAT ACM PANELS TO BE ROUTED AND FOLDED |
| 14 CUSTOM BLUE HARDWARE. LOW SIDE OF DOOR PULL ON HINGE SIDE OF DOOR | 35 PROVIDE EYE HOOK FOR PATIO STRING LIGHTS |
| 15 ALIGN BATTEN / LENTICULAR OVER ACM PANEL SEAM | 36 WALK-IN UNIT TO HAVE FACTORY FINISH |
| 16 ACM PANEL SEAM, TYPICAL | 37 EYEBROW / SOFFIT TO STOP AT WALK-IN UNIT |
| 17 GAS SERVICE | 38 HEAVY DASHED LINE INDICATES PARAMETER OF WALK-IN UNIT |
| 18 GREASE EXTRACTION SYSTEM CONNECTION 4'-4" TO CENTER (PLACE BETWEEN LENTICULARS) | 39 EYEBROW AT COVERED PATIO TO ALIGN WITH BUILDING EYEBROW. SEE PATIO ELEVATIONS FOR CONTINUATION. |
| 19 ADA RESTROOM SIGNAGE - REFER TO B1.01 FOR ADDITIONAL INFORMATION | |
| 20 ELECTRICAL SERVICE | |
| 21 DASHED LINES INDICATE ROOF MOUNTED EQUIPMENT - BEYOND | |


COLOR SCHEDULE

- | | |
|---|---|
| CLAD-1
ACM METAL PANEL CLADDING (FLAT)
COLOR: SAW WHITE
LOT: 040519 / STOCK
MANUF.: ALPOLIC PANELS
SIZE: 60" X 118" X 5/16" | CLAD-4
ACM METAL PANEL CLADDING
COLOR: ABE BLUE
LOT: 060419 / STOCK
MANUF.: ALPOLIC PANELS |
| CLAD-2
ACM METAL PANEL CLADDING
COLOR: BYL YELLOW
CUSTOM PRINTED GRAPHIC | CLAD-5
ACM METAL PANEL CLADDING (FLAT)
COLOR: BYL YELLOW
MANUF.: ALPOLIC PANELS
SIZE: 60" X 118" X 5/16" |
| CLAD-3
WOOD LOOK METAL CLADDING
COLOR: SONIC CUSTOM
MANUF.: KNOTWOOD | GL-1
ALUMINUM GLAZING SYSTEM
MANUF.: KAWNEER
SIZE: CLEAR ANODIZED
HARDWARE COLOR: SATIN CHROME 626 |
| P-1
SONIC LOGO MEDIUM BLUE PAINT
PRODUCT #: B66T01554
MANUF.: SHERWIN WILLIAMS
DESCRIPTION: PI MULTI ACR SG UD
GALLON FORMULA: W1-4y33, L1-4y11+1, R3-19+1 | P-5
SONIC DARK BLUE PAINT
PRODUCT #: B66T01554
MANUF.: SHERWIN WILLIAMS
DESCRIPTION: PI MULTI ACR SG UD
GALLON FORMULA: W1-2y61+1, L1-4y57+11, R3-2y53+1, Y-19 |
| P-2
SONIC CONFIDENT YELLOW PAINT
PRODUCT #: B66Y01157
MANUF.: SHERWIN WILLIAMS
DESCRIPTION: PI DTM SG VV YEL | P-6
SONIC FROST BLUE PAINT
PRODUCT #: B66W01551
MANUF.: SHERWIN WILLIAMS
DESCRIPTION: PI MULTI ACR SG EW
GALLON FORMULA: L1-52+01 |
| P-3
SONIC ARCHITECTURAL RED PAINT
PRODUCT #: B66T01554
MANUF.: SHERWIN WILLIAMS
DESCRIPTION: PI MULTI ACR SG UD
GALLON FORMULA: R4-14y | P-7
7659 GRIS PAINT
PRODUCT #: B54T00104
MANUF.: SHERWIN WILLIAMS
DESCRIPTION: INDUSTRIAL ENAMEL ULTRADE
CLEAR TINT BASE |
| P-4
SONIC PURE WHITE PAINT
PRODUCT #: B66W01551
MANUF.: SHERWIN WILLIAMS
DESCRIPTION: PI MULTI ACR SG EW
GALLON FORMULA: B1-+01, Y3-+1 | L-1
SONIC LOGO MEDIUM BLUE
PSS 4009 |
| | L-2
SONIC CONFIDENT YELLOW PSS 2834 |
| | L-3
SONIC ARCHITECTURAL RED
T.B.D. |
| | L-4
SONIC PURE WHITE
PSS 4950 |
| | L-5
SONIC DARK BLUE
PMB 1710 |
| | L-6
SONIC FROST BLUE
PMS 2197C |

GENERAL NOTES

- DIMENSIONS OF REVEALS ARE TO CENTERLINE - VERIFY GRADE PRIOR TO CONSTRUCTION
- DO NOT SCALE DRAWINGS - CONTACT ARCHITECT FOR ANY DISCREPANCIES ARE FOUND
- REFER TO CANOPY DRAWINGS FOR ADDITIONAL PREMANUFACTURED CANOPY INFORMATION


G 141 ARCHITECTURE LLC

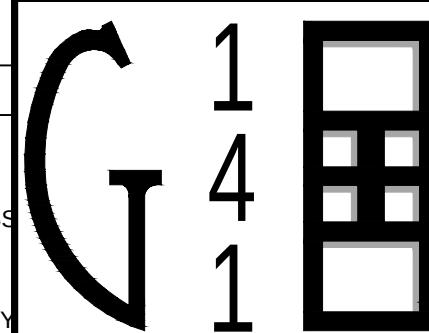

ARCHITECTURE, L.L.C.

ROBERT ANTHONY GRIMALDI
39 NORTH 11th STREET
KENILWORTH, NJ 07033
g141office@gmail.com
908-347-7419
NCARB 84690
AIA 38640695

CT 13585
DE S5-0008497
DC AEC103027
MA 951751
MD 18745
NJ AI 15475
NH 04842
NY 039330
OH ARC.2018210
PA AR07639
VA 0401019058

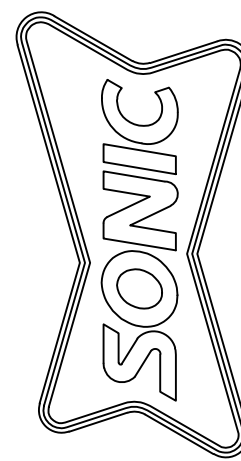

SONIC DRIVE-IN RESTAURANT
470 EALGE ROCK AVE
WEST ORANGE, NJ - 07052

PROPOSED EXTERIOR ELEVATION
OPEN PATIO VERSION

Revisions

- △:
- △:
- △:
- △:
- △:

Drawn By

MC

Checked By

RAG

Scale

AS NOTED

Date

2023-05-04

Job No.

23-0027

Sheet No.

PB-3

THIS DRAWING IS COPYRIGHTED AND PROTECTED UNDER THE LAWS OF THE UNITED STATES OF AMERICA. ANY UNAUTHORIZED USE OR REPRODUCTION OF THIS DOCUMENT WITHOUT WRITTEN CONSENT OF ROBERT A. GRIMALDI IS AN INFRINGEMENT UPON COPYRIGHT LAWS. VIOLATORS WILL BE SUBJECT TO PROSECUTION BY THE FULL EXTENT OF THE LAW.

BUILDING 15 2020 EQUIPMENT SCHEDULE										ELECTRICAL					PLUMBING				GAS			
EQ #	DESCRIPTION	QTY	ALT	MANUFACTURER	MODEL	REMARKS	NOTES:	SUPPLIED & INSTALLED BY EQ. VENDOR	SUPPLIED BY EQ. VENDOR	INSTALLED BY G.C.	SUPPLIED & INSTALLED BY G.C.	VOLT	PHASE	HORSEPOWER	NEMA	KVA/AMPS	AMP	HOT WATER	COLD WATER	WASTE	CONNECTION	METHOD
1	ICE CREAM MACHINE (AIR COOLED)	1	A	ELECTRO FREEZE	GEN-5420 (DUAL HEAD ICE CREAM)		1					208	3	(2) 2.0	VERIFY		VERIFY					
			A	STOBELTING	UA21-H2 A/C (DUAL HEAD ICE CREAM)		1					208	3	(2) 2.0	VERIFY		VERIFY					
		1	C	ELECTRO FREEZE	GEN-80 (SINGLE SHAKE)		1					208	3	1 1/2	VERIFY		10.3					
2	ICE CREAM CLIP AND CONE DISPENSER	1	A	STOBELTING	BU412 (SINGLE SHAKE)		1					208	1	3/4	VERIFY		VERIFY					
3	REFRIGERATED FOUNTAINETTE	1	A	CUSTOM STAINLESS STEEL FAB. (NSF)	OVERHEAD HANGING DISPENSER	TO BE USED WHEN PLACED ABOVE SINGLE SHAKE OR ICE CREAM																
4	STAINLESS STEEL TABLE	1	B	CUSTOM STAINLESS STEEL FAB. (NSF)	MACHINE MOUNTED	TO BE USED WHEN PLACED ABOVE DUAL OR COMBO UNITS																
		1	C	CUSTOM STAINLESS STEEL FAB. (NSF)	14" DEPTH X LENGTH SHOWN WITH TAG #	INCLUDES DOUBLE UNDERSHELF						115	1	1/4	5-15		3.4					
5	FOUNTAIN ORGANIZER	1	C	CUSTOM STAINLESS STEEL FAB. (NSF)	30" DEPTH X LENGTH SHOWN WITH TAG #	INCLUDES DOUBLE UNDERSHELF																
6	TABLETOP MIXER	0	A	HAMILTON BEACH	36" DEPTH X LENGTH SHOWN WITH TAG #	INCLUDES DOUBLE UNDERSHELF																
		1	B	CUSTOM STAINLESS STEEL FAB. (NSF)	36" RACK WHEN 36" FOUNTAINETTE IS SELECTED	INCLUDES DOUBLE UNDERSHELF																
7	HOT FLUDGE WARMER/SERVER	1	B	ELECTRO FREEZE	94950							120	1	3/4			5.2					
8	COFFEE AND TEA BREWER	1	B	ELECTRO FREEZE	HMD75A							115	1	3/4			10.0					
9	COFFEE AND TEA DISPENSERS	1 SET	B	SERVER PRODUCTS	FSP 82060	PART OF SMALLWARES PACKAGE USED ON TABLE #4 OR #3	3					120	1		5-15P		4.2					
10	SLUSH DRINK MACHINE (AIR COOLED)	2	A	BUNN	TCB-2V-DRB WITH INTEGRATED FLIP TRAY	PROVIDE POWER AND FILTERED WATER CONNECTION	3					120	1	VERIFY	5-15P		14.0	1/2		1/2		
		2	B	ELECTRO FREEZE	TDO-N-3.5, RSVR		1					208	1	1/2	6-20		35.0					
10.1	SLUSH RACK	2	B	ELECTRO FREEZE	50 2188		1					208	1	1/2	6-20P		12.0					
11	SLUSH FILL STATION (PROVIDED BY COKE)	2	B	CUSTOM STAINLESS STEEL FAB. (NSF)																		
12	ULTIMATE DRINK MACHINE WITH ICE BIN	2	A	LANCER	85-0084-01		4					V	V	VERIFY	VERIFY		VERIFY	V	V			
13	DRINK CLIP AND LID DISPENSER	1	A	COCA-COLA	85-2406C-122V, IC 45866		4					120	1	VERIFY	VERIFY		13.3	V	V			
		1	B	CUSTOM STAINLESS STEEL FAB. (NSF)		OVERHEAD HANGING DISPENSER - HOP TABLE																
14	DRINK CONDIMENT TABLE	2	A	CUSTOM STAINLESS STEEL FAB. (NSF)	36" CUSTOM STAINLESS STEEL FAB. (NSF)	OVERHEAD HANGING DISPENSER - DT AREA																
15	STAINLESS STEEL CHASE (U-SHAPED @ WALL)	2	C	SCDA MACHINE MOUNTED CUSTOM STAINLESS STEEL RACK (NSF)	36" X 12" X 120" STAINLESS STEEL FAB (NSF)	MACHINE MOUNT TIGHT TO CEILING																
16	DRIVE THRU STATION	1	C	CUSTOM STAINLESS STEEL FAB. (NSF)	36" DEPTH X LENGTH SHOWN WITH TAG #	SINGLE TABLE INCLUDES COLDWELL & DOUBLE UNDERSHELF																
17	LEMONADE DISPENSER	1	D	18" X 24" ROLLING CART	8" X 30" DRINK RAIL	MOUNT TIGHT TO CEILING																
18	HOP TABLE	1	C	CRATHCO BY GNCW	SIMPLICITY BUBBLER MINI-TWIN CS-2E-16							115	1	1/10			3.6					
19	WALL MOUNTED FIRE EXTINGUISHER	2	A	CUSTOM STAINLESS STEEL FAB. (NSF)	2A-10-8C		5															
20	WALL MOUNTED HAND SINK	1	B	SUPPLY LOCALLY	2A-C-K		5															
21	COMBINATION EXPO / HOP TABLE	2	A	ELKAY	EHS-18-SSX	SPLASH GUARD BOTH SIDES OF SINK						120	1		5-15P		(2) VERIFY	1/2	1/2	2		
22	STAINLESS STEEL TABLE (SALT & BAG)	1	A	CUSTOM STAINLESS STEEL FAB. (NSF)	30" DEPTH X 96" LENGTH	TABLE W/ WARMERS AND SACK RACK																
23	TEA URN SHELF	2	C	CUSTOM STAINLESS STEEL FAB. (NSF)	30" DEPTH X 48" LENGTH	SINGLE UNDERSHELF - FREEZER																
24	36" DOUBLE DOOR UNDERCOUNTER FREEZER	1	B	TBD	TBD							115	1	1/4	5-15P		5.7					
25	VERTICAL HOLDING UNIT	1	A	PRINCE CASTLE - FRYER	DHB4PT-20A 8 UNIT							120	1		5-20P		13.3					
26	SALT & BAG HOLD UNIT	1	C	CUSTOM STAINLESS STEEL (NSF)								208	1		5-20P		20.0					
27	FRY TIMER	1	A	AJ ANTUNES EST-3																		
28	GRILL/FRYER EXHAUST HOOD SYSTEM	1	A	STRATOVENT MODELS/VNDZ (NSF)	12'-0" LENGTH - CANOPY STYLE	NO MAKEUP AIR																
29	EXHAUST HOOD INTERLOCK BOX	1	B	HOOD MANUFACTURER																		
30	FRYERS	1	F	HENRY PENNY (GAS 4 BANK) WITH GREASE TRANSFER SYSTEM	EE0344-01	COMES WITH GAS CONNECTION	1					120	1		5-20R		12.2					
31	REACH IN FREEZER	2	A	BEVERAGE AIR	HE1-1HS							115	1	1/2	5-20R		7.8					
32	REACH IN REFRIGERATOR	1	B	TRAULSEN	SNGL12000							115	1	1/2	5-15P		9.7					
33	FIRE SUPPRESSION SYSTEM CONTROL BOX	1	B	TRAULSEN	HR1-1HS							115	1	1/2	5-20R		5.8					
34	GRILL / GRIDDLE	1	A	ANGUL	G10001							115	1	1/2	5-15P		6.1					
35	COOKING TIMER	1	A	FLAT GRILL - GARLAND (GAS) WITH STAND	B-105	INCLUDE GAS CONNECTION KIT #40.2	5					120	1		VERIFY		1					3/4
36	GAS HOSE	1	A	AJ ANTUNES TTS-8	60" CG-60F																	
37	EXPEDITE TABLE WITH WARMERS AND SACK RACK	1	C	DORMONT - 3/4"																		
38	REFRIGERATED TABLE (DRESSER) - SINGLE SIDED	1	A	80" CUSTOM STAINLESS STEEL WITH PASS SHELF/WARMER (NSF)	SPER0-24M							120	1		5-15P		(3) VERIFY					
39	HORIZONTAL HOLDING UNIT	1	C	BEVERAGE AIR (NSF)	HE1-1HS							115	1	1/2	5-15P		9.6					
40	TOASTER AND WARMER TABLE	1	E	PRINCE CASTLE	DHB2SS-33SNCGR 8 UNIT							208	1		6-15P		10.8					
41	STEAMER	2	C	CUSTOM STAINLESS STEEL (NSF)	30" X 38" SINGLE SIDED							120					20					
42	BUN TOASTER	1	B	ROUNDUP	MS-255 / 7000314	PROVIDE POWER AND FILTERED WATER CONNECTION						208	1		6-20P		15.9					1/4
43	WARMER SHELF / BAG RACK (SINGLE SIDED)	1	B	CUSTOM STAINLESS STEEL (NSF)	GST-3V (SMALLER UNIT)							208	1		6-20P		20.0					
44	COUNTERTOP WARMERS	1	A	ROUNDUP		TRADITIONAL KITCHEN ONLY																
45	HOT / COLD COMBO CONEY TABLE	1	E	CUSTOM STAINLESS STEEL (NSF)	CW100							120	1		5-15P		12.5					
46	HOT DOG WARMER/HOLDING DRAWER	1	B	ROUNDUP	WD-50							120	1		5-15P		15.0					
47	HOT DOG CAROUSEL	1	B	ROUNDUP	HDC-50A							120	1		5-15P		11.7					
48	PREP TABLE (ROLLING)	1	B	CUSTOM STAINLESS STEEL (NSF)	30" DEPTH X LENGTH SHOWN WITH TAG #							120	1		5-15P		14.8					
49	MANAGER'S DESK	1	B	CUSTOM STAINLESS STEEL (NSF)	24" DEPTH X LENGTH SHOWN WITH TAG #																	
50	MANAGER'S UPPER SHELVING	2	METRO	18" DEPTH X LENGTH SHOWN WITH TAG #																		
51	FILE CABINET	1	A	VERTICAL FOUR DRAWER ON CASTERS																		
52	POS AND VIDEO RACK	2	A	VANES - REFER TO ELECTRICAL		REFER TO ELEVATIONS ON ELECTRICAL SHEETS																
53	SAFE	1	A	SMART SAFE	CS8820 DROP SAFE	28" X 20 1/2" X 16"D																
54	ICE MACHINES REMOTE CONDENSERS	2	A	SCOTSMAN	ERC311-32A		2					208	1		VERIFY		2.7		V	3/4		
55	ICE STORAGE BIN	1	A	FOLLETT	SG14905-60																	
56	ICE MACHINES (AIR COOLED)	2	A	SCOTSMAN	N1322R-32 / RTE-25 - 1300 LB. NUGGET		2					208	1		VERIFY		18.9		3/8	3/4		
57	BREAD RACK	9	C	SUPPLY LOCALLY		FROM BAKERY VENDOR																
58	GREASE REMOVAL TANK	1	C	DARLING - GRIFFIN	R.O.S.S. STORAGE	DARPRO LEASE UNIT						110	1									
59	3-COMPARTMENT SINK W/24" DRAINBOARDS	1	E	ELKAY	FSP20471																	3
60	PRE-RINSE UNIT (FOR 3-COMP SINK)	1	A	T&S BRASS	B-133, B-109, B-159LN, 63X																	
61	EPOXY MODULAR WALL SHELF SYSTEM (SMARTWALL)	1	B	METRO	BEHND-3 COMP SINK																	3/4
62	CHROME WIRE STORAGE SHELVING	1	C	METRO	DEPTH X LENGTH SHOWN WITH TAG #	LOWER DUNNAGE AND 4 TIER WITH CASTERS																
63	CHROME WIRE DUNNAGE SHELVING	1	B	METRO	DEPTH X LENGTH SHOWN WITH TAG #	LOWER DUNNAGE AND 5 TIER WITH CASTERS																
64	CHROME WIRE DUNNAGE SHELVING	1	C	METRO	DEPTH X LENGTH SHOWN WITH TAG #	(4) DUNNAGE TIER																
65	ALUMINUM DUNNAGE RACK	1	B	NEWAGE		4 TIER																
66	BAG-IN-BOX STORAGE UNIT	1	A	COCA-COLA	43142		3															
67	DRINK CARBONATOR TANK WITH 6" SS LEGS	1	A	LOCAL CO2 VENDOR		750 POUND TANK WITH SMALL TANK HOOK-UP	4					115	1	1/3	VERIFY		4.4					
68	SLUSH PRECHILLER (SUPPLIED BY COKE)	1	A	LANCER	1500		4															
69	SLUSH RACK (SUPPLIED BY COKE)	1	A	LANCER	51-1408		4															
70	MOP SINK	1	A	BY GENERAL CONTRACTOR	24" X 24" PREFORMED	REFER TO PLUMBING FOR FAUCET SPECIFICATIONS																
71	PRESSURE WASHER	1	A	EASWASH	25200 - 14" X 36" SHELF		6					208	1	5.0			30.0	1/2	1/2			
72	EMPLOYEE LOCKERS	1	A	LOCAL SUPPLIER																		
73	WATER HEATER	1	A	LOCAL VENDOR		REFER TO PLUMBING SHEETS FOR SPECIFICATIONS																
74	MOP/BROOM HANGER RACK	1	B	RUBBERMAID	199300 (36")																	
75	COAT RACK	1	A	LOCAL VENDOR	1HE25 (20")																	
76	COOLER COIL/FAN UNIT AND REMOTE CONDENSER	0	A	KOLPAK																		
77	FREEZER COIL/FAN UNIT AND REMOTE CONDENSER	0	A	KOLPAK			2															
78	WALK-IN COOLER/FREEZER	1	A	KOLPAK			2															
79	WATER FILTRATION SYSTEM	1	A	ALTUNES	VZN-421H-TS							110	1				0.08				3/4	3/4
80																						

THIS DRAWING IS COPYRIGHTED AND PROTECTED UNDER THE LAWS OF THE UNITED STATES OF AMERICA. ANY UNAUTHORIZED USE OR REPRODUCTION OF THIS DOCUMENT WITHOUT WRITTEN CONSENT OF ROBERT A. GRIMALDI IS AN INFRINGEMENT UPON COPYRIGHT LAWS. VIOLATORS WILL BE SUBJECT TO PROSECUTION BY THE FULL EXTENT OF THE LAW.



G 141 ARCHITECTURE, LLC


G141

ARCHITECTURE, LLC

ROBERT ANTHONY GRIMALDI
39 NORTH 11th STREET
KENILWORTH, NJ 07033
g141office@gmail.com
908-347-7419

NCARB 84690
AIA 38640695

CT	13585
DE	S5-0008497
DC	AEC103027
MA	951751
MD	18745
NJ	AI 15475
NH	04842
NY	039330
OH	ARC.2018210
PA	AR07639
VA	0401019058

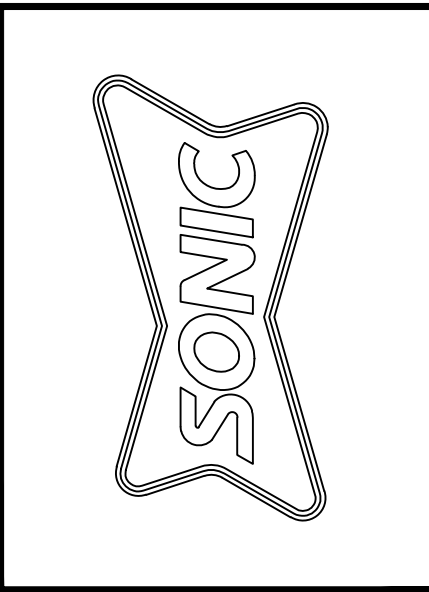

SONIC DRIVE-IN RESTAURANT
470 EALGE ROCK AVE
WEST ORANGE, NJ - 07052

PROPOSED EXT. ELEVATION PICTURES
OPEN PATIO VERSION

Revisions	
△:	
△:	
△:	
△:	
△:	
△:	
Drawn By	Checked By
MC	RAG
Scale	Date
AS NOTED	2023-05-04
Job No.	23-0027
Sheet No.	PB-5