


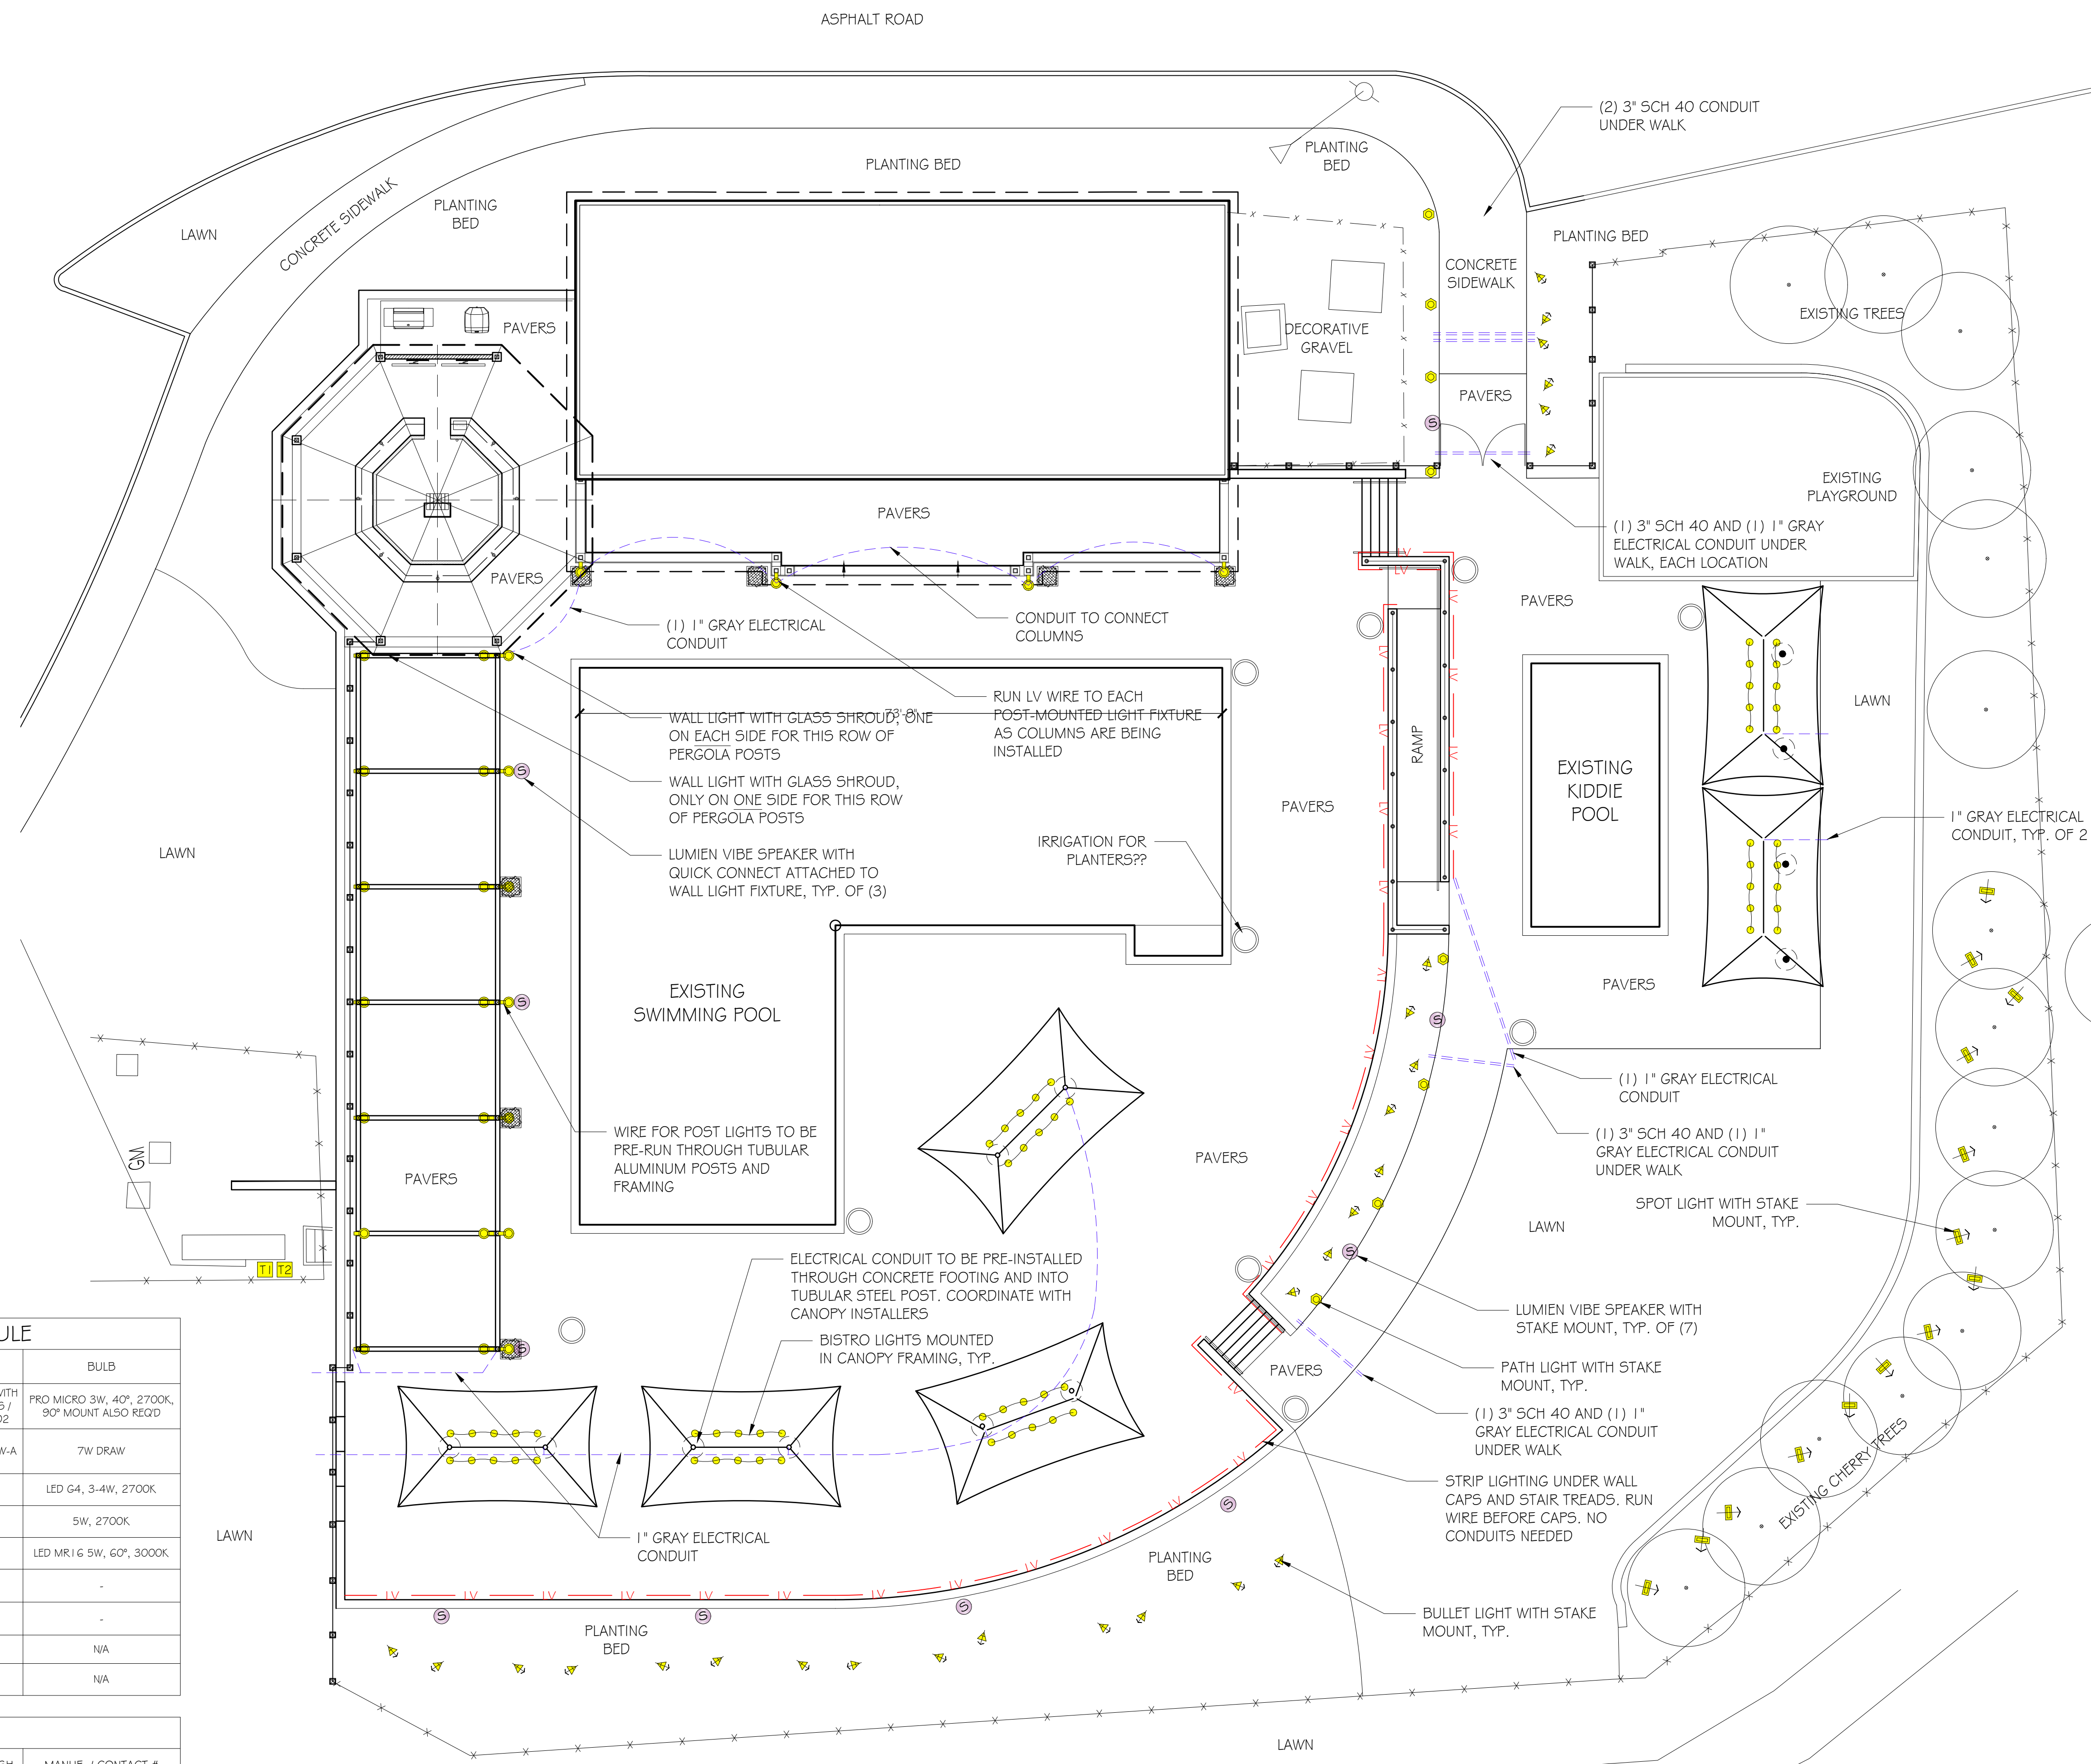

LANDSCAPE LIGHTING SCHEDULE				
KEY	QTY.	ITEM DESCRIPTION	MANUFAC. / MODEL #	BULB
	25	WALL LIGHT WITH GLASS SHROUD	LUMIN MICRO PRO MODULE WITH 1 3" GLASS SHROUD, BUBBLES / M881-3W-27K-40-A # LAG-02	PRO MICRO 3W, 40°, 2700K, 90° MOUNT ALSO REQD
	10	SPEAKERS, 3 WALL MOUNT, 7 GROUND MOUNT	LUMIN VIBE SPEAKER / LV-40W-A	7W DRAW
	8	PATH LIGHT	MILLENNIUM BOLLARD	LED G4, 3-4W, 2700K
	14	BRASS BULLET SPOT LIGHT FOR EXISTING TREES	-	5W, 2700K
	28	BULLET UPLIGHT	-	LED MR16 5W, 60°, 3000K
	140 FT	BISTRO LIGHTS WITH 5.5, SUPPORT CABLE, 10 FT	-	-
	280 FT	STRIP LIGHT ON WALLS # STEPS	-	-
	2	TRANSFORMER	-	N/A
	1	BRILLIANCE SCENE SELECTOR		N/A

PLANTER SCHEDULE				
KEY	QTY.	ITEM	MODEL / COLOR / FINISH	MANUF. / CONTACT #
	7	MODERN FIBERGLASS SQUARE PLANTER, 24" SQ. x 24" HIGH	F1-MAR-52424-CH / CHARCOAL / MATTE FINISH	Planters Unlimited Carlsbad, Ca 92011 (888) 320-0626
	10	MODERN FIBERGLASS TAPERED PLANTER, 36" ROUND x 3' HIGH	F1-MOD-TR3036-CH / CHARCOAL / MATTE FINISH	Planters Unlimited Carlsbad, Ca 92011 (888) 320-0626

GENERAL LEGEND

	PROPERTY LINE
	SETBACK LINE
	CASIMENT
	EXISTING FENCE
	LIMIT OF DISTURBANCE
	SILT FENCE
	GAS LINE
	WATER LINE / PLUMBING
	SAFARIY SEWER LINE
	DRAIN PIPE, SOLID
	DRAIN PIPE, PERFORATED
	LOW VOLTAGE / DATA
	ELECTRIC, 120V
	SLEEVES FOR LIGHTING, IRRIGATION
	STAIR RISER
	CONTOUR, EXISTING
	CONTOUR, PROPOSED
	EXISTING ELEVATION, DISTING
	PROPOSED ELEVATION, PROPOSED
	HOUSE GRESS / DOOR
	FENCE GATE / DOOR SWING
	AC UNIT
	WINDOW WELL
	DOWNSPOUT, BURIED
	ROSE BIB
	IRRIGATION VALVE BOX
	ELECTRIC METER
	ELECTRIC OUTLET
	ELECTRICAL SWITCH
	GAS METER
	DRAIN INLETS
	FIRE HYDRANT
	STREET CATCH BASIN
	TELEPHONE POLE
	WATER AND GAS VALVES
	EXISTING TREE TO REMAIN
	EXISTING SHRUB TO REMAIN

PREPARED BY:



LANDSCAPE
SPONZILL
GROUP INC.
STAND APART™

345 PASSAIC AVENUE
FAIRFIELD, NJ 07004
P: (973) 244-1410
W: www.sponzilli.com

DATE		REVISIONS / SUBMITTALS

PROJECT:

**ESSEX COUNTY
COUNTRY CLUB**
350 Mt Pleasant Ave
West Orange, NJ 07052


DRAWING SET:

LANDSCAPE SET

PLAN TITLE:


LANDSCAPE LIGHTING PLAN

Date:	7/3/2024
Scale:	1"=10'-0"
Project No.:	
Drawn By:	AL
Checked By:	AL
Sheet No:	2 of 3
Drawing No:	

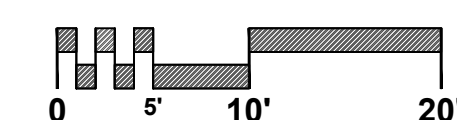

PLANT LIST - OUTSIDE POOL AREA				
Key	Qty	Botanical Name	Common Name	Size/Condition
Trees				
Li	3	Lagerstroemia indica	Crape Myrtle	7-8'
Shrubs				
Hpl	11	Hydrangea paniculata 'Limelight'	Limelight Hydrangea	5g
RCD	14	Rosa x 'Coral Drift'	Coral Drift Rose	3g
SGF	16	Spiraea 'Gold Flame'	Gold Flame Spirea	5g
Perennials				
Per	107	Perennial	Perennial	1g

PLANT LIST - INSIDE POOL AREA				
Key	Qty	Botanical Name	Common Name	Size/Condition
Trees				
Ck	7	Cornus kousa	Kousa Dogwood	8-10'
FSD	3	Fagus Sylvatica Dawyck Purple	Purpleleaf European Beech	2-2.5' cal
Shrubs				
BLB	14	Buddleia 'Lo & Behold® 'Blue Chip'	Lo & Behold® 'Blue Chip' Butterfly Bush	3g
Bwg	16	Buxus microphylla var. 'Koreana 'Winter Gem'	Winter Gem Boxwood	24-30"
HmE	33	Hydrangea macro 'Endless Summer'	Endless Summer Hydrangea	5g
SAW	13	Spiraea 'Anthony Waterer'	Anthony Waterer Spirea	3g
WFS	10	Weigela florida 'Spilled Wine'	Spilled Wine Weigela	5g
Ornamental Grasses				
PaH	17	Pennisetum alopecuroides 'Hameln'	Dwarf Fountain Grass	3g
Perennials				
PaL	30	Perovskia atrnpicifolia 'Little Spire'	Little Spire Russian Sage	1g

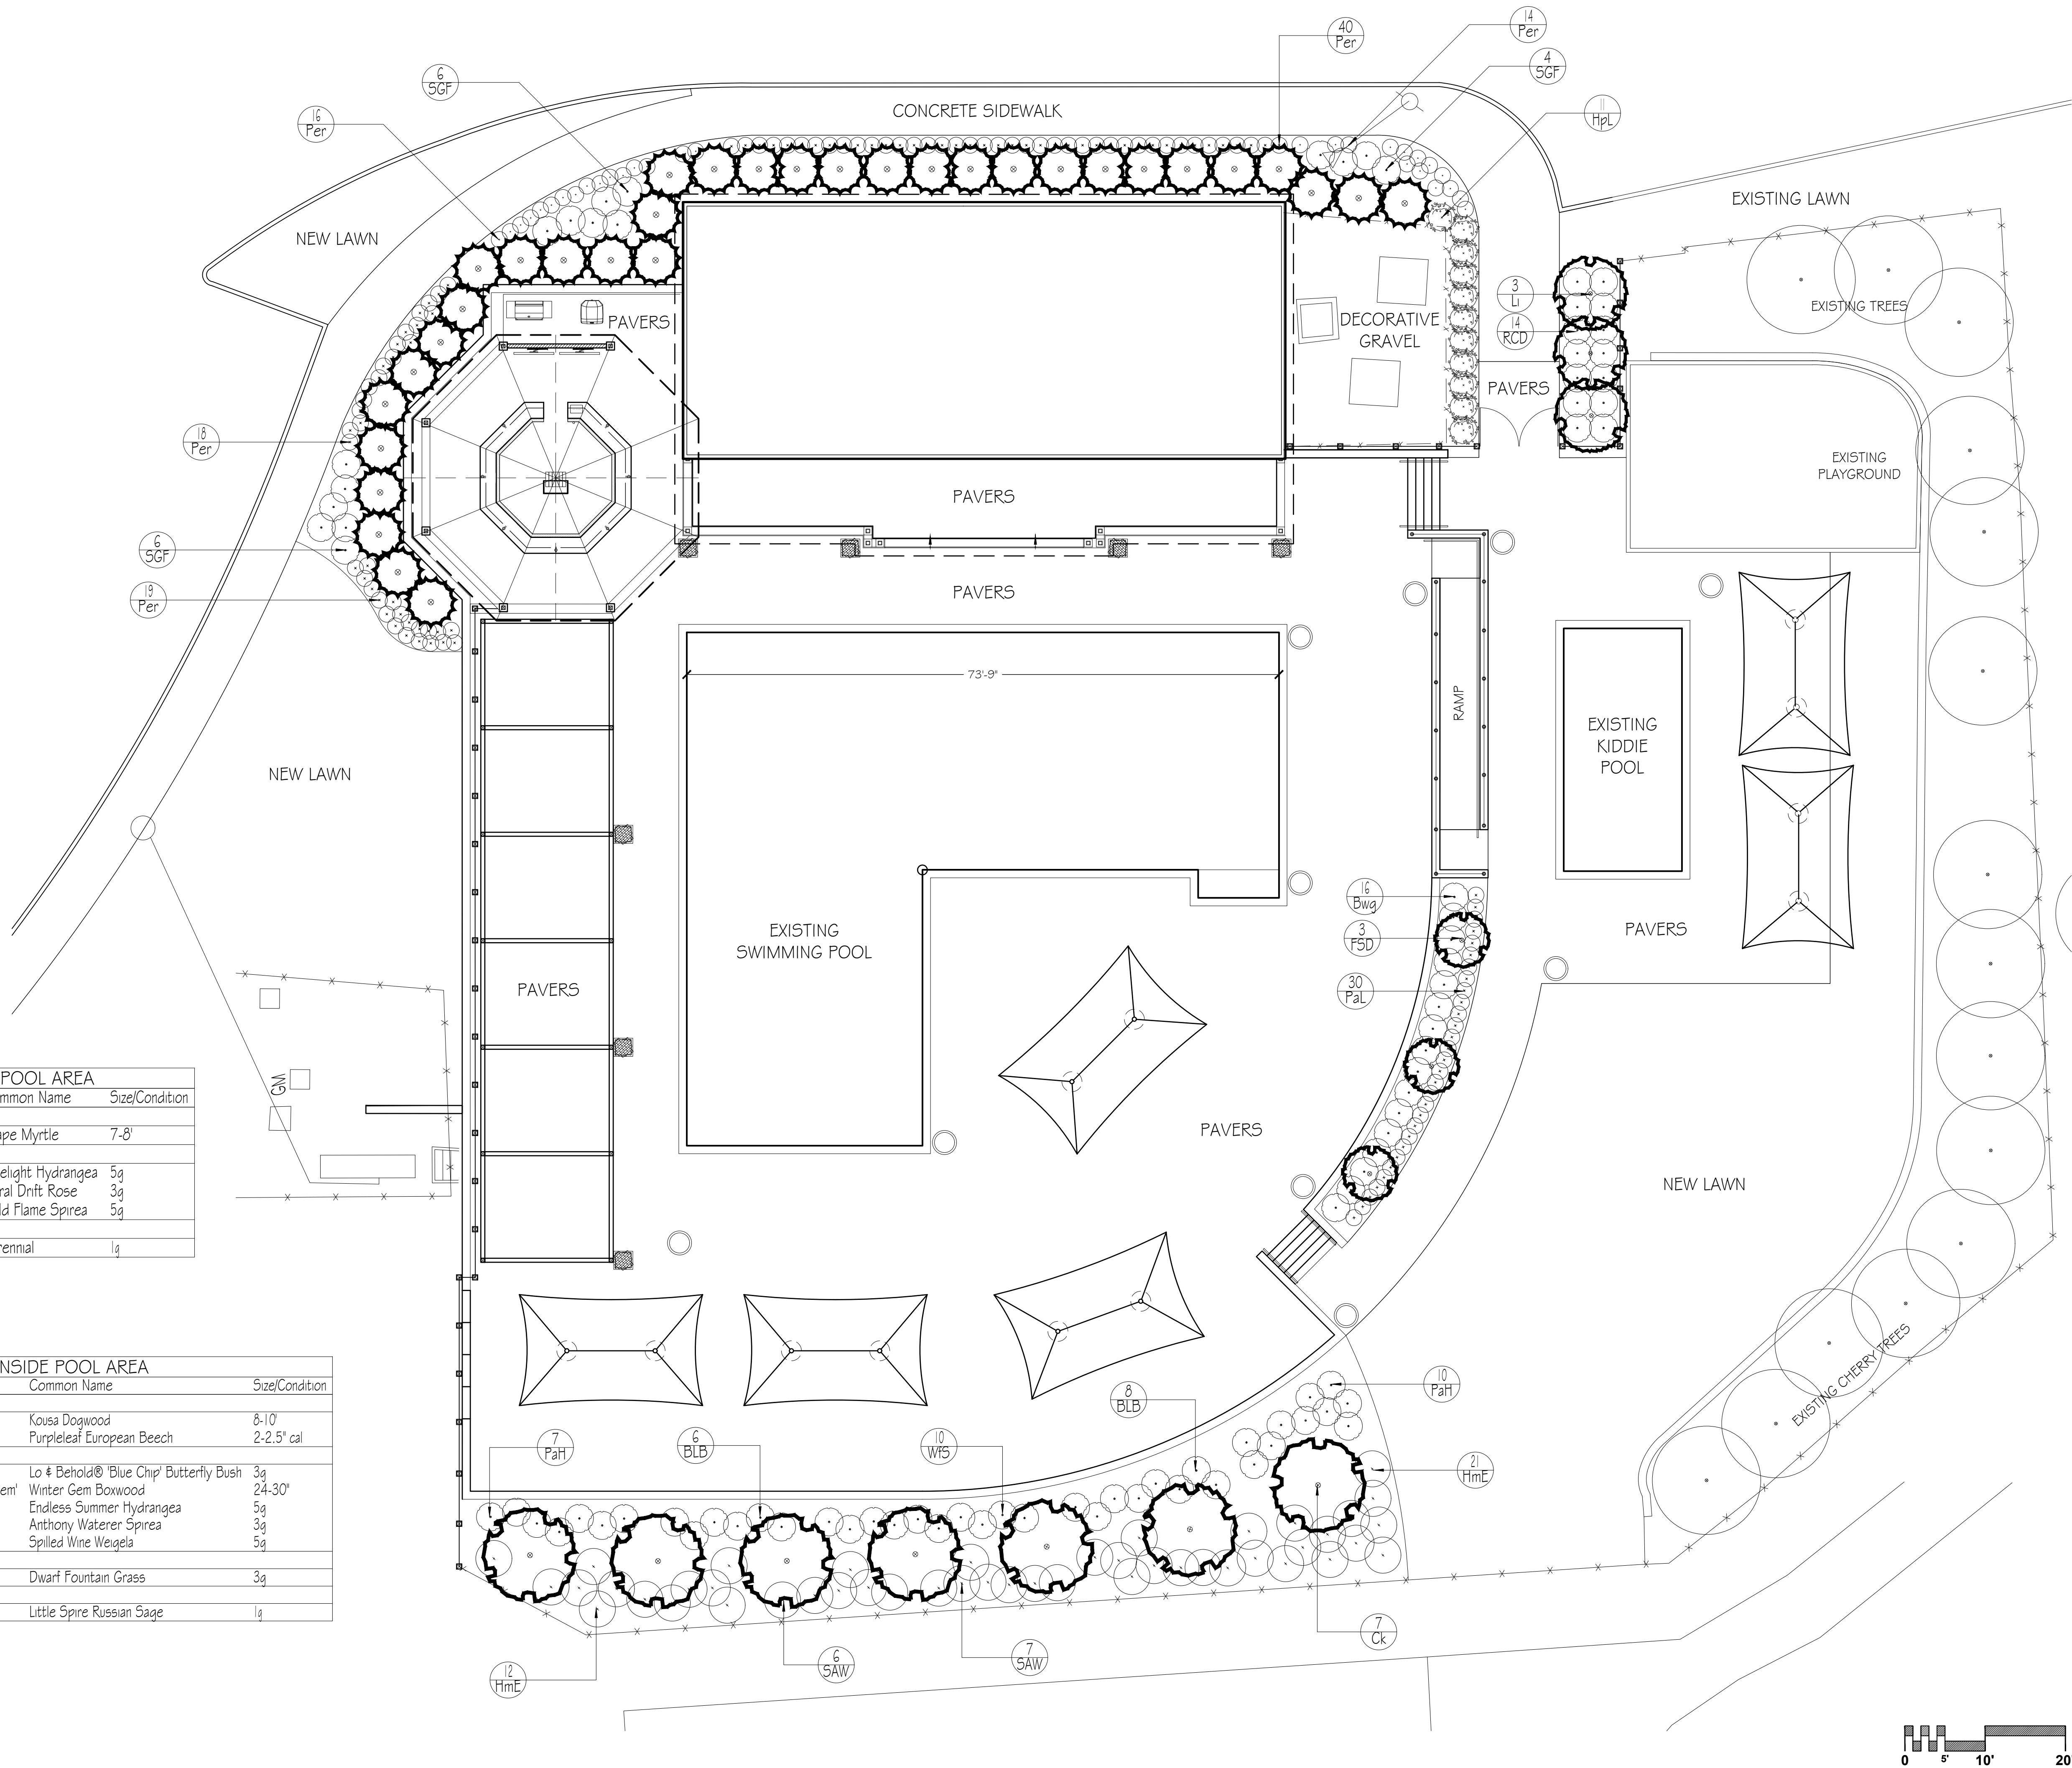

GENERAL LEGEND	
	PROPERTY LINE
	SETBACK LINE
	EASEMENT
	EXISTING FENCE
	LIMIT OF DISTURBANCE
	SILT FENCE
	GAS LINE
	WATER LINE / PLUMBING
	SANITARY SEWER LINE
	DRAIN PIPE, SOLID
	DRAIN PIPE, PERFORATED
	LOW VOLTAGE / DATA
	ELECTRIC, 120V
	SLEEVES FOR LIGHTING, IRRIGATION
	STAIR RISER
	CONTOUR, EXISTING
	CONTOUR, PROPOSED
	SPOT ELEVATION, EXISTING
	SPOT ELEVATION, PROPOSED
	HOUSE EGRESS / DOOR
	FENCE GATE / DOOR SWING
	A/C UNIT
	WINDOW WELL
	DOWNSPOUT, BURIED
	HOSE BIB
	IRRIGATION VALVE BOX
	ELECTRIC METER
	ELECTRIC OUTLET
	ELECTRICAL SWITCH
	GAS METER
	DRAIN INLETS
	FIRE HYDRANT
	STREET CATCH BASIN
	TELEPHONE POLE
	WATER AND GAS VALVES
	EXISTING TREE TO REMAIN
	EXISTING SHRUB TO REMAIN

PREPARED BY:



345 PASSAIC AVENUE
FAIRFIELD, NJ 07004
P: (973) 244-1410
W: www.sponzilli.com

DATE REVISIONS / SUBMITTALS

DATE	REVISIONS / SUBMITTALS

PROJECT:

ESSEX COUNTY COUNTRY CLUB

350 Mt Pleasant Ave
West Orange, NJ 07052

DRAWING SET:

LANDSCAPE SET

PLAN TITLE:

PLANTING PLAN



ANDREW J. LASTELLA
Licensed Landscape Architect
NJ License #21A500098600

Date: 7/3/2024
Scale: 1"=10'-0"
Project No.:
Drawn By: AL
Checked By: AL
Sheet No: 3 of 3
Drawing No:

L-3

